949-724-6000



City of Irvine, 1 Civic Center Plaza, P.O. Box 19575, Irvine, California 92623-9575

October 23, 2025

Mr. Terry Smith Rengel & Company Architects 333 El Camino Real Tustin, CA 92780 **Sent Via Email:** 

tsmith@rengelarch.com

Subject: Approval of Modification 00957990-PMPC to Master Plan 00434337-

PMP for the Community Ice Facility located at 888 Ridge Valley in

Planning Area 51 (Great Park)

Dear Mr. Smith:

Community Development Department staff reviewed Minor Modification 00957990-PMPC for a proposed expansion of the existing community ice facility for the Anaheim Ducks. The project site is zoned 8.1 Trails and Transit Oriented Development and is within Planning Area 51 (Great Park).

In August 2007, the Planning Commission approved the Great Park Master Plan (File No. 00434337-PMP) for the conceptual design of a 1,145-acre park with passive and active features. In 2011, the City approved a Great Park Master Plan Modification 00524784-PMP for the development of a community ice facility. Subsequent to this approval, the City approved Master Plan Modification 00661956-PMPC to refine the previously approved conceptual design and approved a four-sheet community ice facility.

The proposed modification seeks to expand the existing building by 3,303 square feet to accommodate training space for the Anaheim Ducks. The expansion will include coach offices, equipment rooms, restrooms, shower facilities, and exercise and trainer areas. Additionally, the project will relocate the northernmost driveway (Driveway A) along Ridge Valley further south to accommodate the location of the building addition and an outdoor workout area, resulting in a reduction of nine parking stalls. The prior driveway area will be re-landscaped and the meandering sidewalk in that area will be replaced. The vehicular gate at the prior location will also be moved to the new location of Driveway A.

Although the proposed modification will increase the building square footage and change the site layout, it will not result in new uses beyond those specified in the Great Park Master Plan.

Section 2-19-2 of the Irvine Zoning Ordinance contains criteria to determine when a proposed modification is classified as a "major modification." A major modification must

Mr. Terry Smith October 23, 2025 Page 2 of 5

be reviewed by the original approving authority at a public hearing. However, where none of the criteria are met, the application is a "minor modification" and reviewed by the Director of Community Development.

Based on the submittal, the Director of Community Development determines that the proposed modification does not meet any of the five criteria to be classified as a major modification. Therefore, the project is a minor modification for the following reasons.

1. Proposed addition, deletion, and/or relocation of approved structures and/or land uses which would cause significant or potentially significant environmental impacts, based on staff's analysis prepared in accordance with City policy.

In 2011, the Planning Commission approved Master Plan Modification 00524784-PMP, which included a 117,635-square-foot community ice facility with three sheets of ice at the Great Park. In 2016, a subsequent master plan modification was approved to refine the conceptual design and add one more sheet of ice. The current proposed modification will not increase the number of sheets of ice but rather would expand the accessory training space for coach offices, equipment rooms, restrooms, shower facilities, and exercise and trainer areas. To accommodate this building expansion and the placement of an outdoor workout area, the existing gated driveway will be relocated, leading to a net loss of nine parking stalls. These changes will not result in any environmental impacts beyond those already evaluated beyond those evaluated during the original approval process.

Pursuant to Section 15153 of the California Environmental Quality Act (CEQA) Guidelines, the community ice facility is within the scope of the project described by the Orange County Great Park Final Environmental Impact Report (FEIR) (State Clearinghouse No. 2002101020) as modified by previously adopted addenda (cumulatively the "Great Park FEIR"). Addendum No. 10 was prepared for the previously approved Great Park Master Plan Modification 00524784-PMP pursuant to Section 15164 of the State of California Environmental Guidelines and concluded that the community ice facility is not anticipated to have any significant effect on the environment.

In addition, the proposed project is exempt under CEQA Guidelines Section 15301, Class 1, Existing Facilities, which applies to projects that consist of minor alterations of existing structures and facilities. The proposed 3,303-square-foot addition will provide additional training spaces will not increase the number of sheets of ice and is in an area where public services and facilities will allow for the maximum development permissible in the General Plan. A Notice of Exemption has been prepared for the project and is attached for reference (Enclosure 2).

2. Proposed addition, deletion and/or relocation of approved structures and/or land uses which would cause significant or potentially significant on-site and off-site traffic impacts, based on staff's analysis of the transportation issues prepared in accordance with City policy.

Mr. Terry Smith October 23, 2025 Page 3 of 5

Transportation Division staff reviewed the proposed relocation of gated Driveway A and its impact on internal site circulation as well as stacking distance from the street. As the new driveway location provides the same amount of stacking area, its location is supportable. Additionally, staff did not identify any onsite impacts with regard to onsite impacts from the driveway relocation or removal of parking spaces associated with the proposed project.

The proposed building expansion to add equipment rooms, coach offices, restrooms, shower facilities, and exercise and trainer areas, as well as the addition of an outdoor training area, is accessory to the existing community ice facility. Because the building expansion is incidental and subordinate to the principal use, it is not anticipated to generate additional vehicle trips or parking needs. Therefore, the project is not anticipated to generate any significant traffic impacts.

3. The intent of the findings and conditions of approval for the approved project would not be preserved.

The intent and use of the site will remain consistent with the previous master plan approval, which includes a community facility with four sheets of ice. The original conditions of approval remain unchanged and in effect. The project will be subject to compliance with all conditions established in the original master plan and subsequent master plan modifications, along with any conditions adopted through subsequent modifications.

4. Proposed addition, deletion, and/or relocation of structures would result in an impact to or introduction of sensitive uses not previously considered within the site. This includes, but is not limited to, uses not previously considered such as childcare centers, schools, residences, and medical establishments.

The project will not impact or introduce sensitive uses not previously considered within the site because the project site was originally approved for a community ice facility. The proposed expansion for additional training area is an accessory use to the existing ice facility with no changes to the number of sheets of ice. Since no new land uses are introduced by this modification, it will not result in an impact to existing, or introduction of new, sensitive uses not previously considered.

5. Reconfiguration of the site plan resulting in: a) a significant reduction of landscaping; or b) a significant change in parking.

The proposed building expansion for the Anaheim Ducks' accessory uses will require site improvements and eliminate nine parking stalls, resulting in a total of 656 stalls. The community ice facility is a part of the larger Great Park, which has parking above the minimum parking requirements through their campus parking program. With the relocation of the driveway, there will be an overall increase in landscaping

Mr. Terry Smith October 23, 2025 Page 4 of 5

by 24 square feet. Therefore, the change in the site plan will not result in a significant change in parking or landscaping.

Based on the information submitted with this application, the Director of Community Development makes the following finding pursuant to Section 2-19-7 of the Zoning Ordinance and hereby approves Minor Modification 00957990-PMPC.

1. The modification does not alter or affect the intent of the findings and conditions of the original project approval.

The modification will not result in a change of use or other significant changes that would substantially alter the findings of and/or conditions applied to the original Great Park Master Plan approval. The modification will expand the training facility to provide a larger space for training and recovery functions for the Anaheim Ducks. All conditions of approval previously established in the original Great Park Master Plan will continue to be applied to this modification. Therefore, the modification is consistent with the intent of the findings and conditions of the original approval.

This approval is subject to the following conditions of approval:

#### Standard Condition 6.1

**DISCRETIONARY CASE CHARGES** 

The applicant is responsible for paying all charges related to the processing of this discretionary case application within 30 days of the issuance of the final invoice or prior to the issuance of building permits for this project, whichever occurs first. Failure to pay all charges shall result in delays in the issuance of required permits or may result in the revocation of the approval of this application.

#### Standard Condition 6.2

LEGAL ACTION - HOLD HARMLESS

In accordance with the provisions of Section 5-5-114 of the Irvine Municipal Code and Government Code Section 66474.9, the applicant shall defend, indemnify, and hold harmless the City of Irvine and its agents, officers, and employees from and against any claim, action, or proceeding against the City agency or its agents, officers, or employees to attack, set aside, void, or annul an approval by the City, including, without limitation, an action by an advisory agency, appeal board, or legislative body concerning this discretionary approval. This defense and indemnification shall include the payment of all legal costs incurred on behalf of the City in connection with the application, and the defense of any claim, action or proceeding challenging the approval. The City will promptly notify the applicant of any claim, action, or proceeding and will cooperate fully in the defense.

In the event a legal challenge to the discretionary approval is successful, and an award of attorney fees is made to the challenger, the applicant shall be responsible to pay the full amount of such an award.

Mr. Terry Smith October 23, 2025 Page 5 of 5

#### Condition 6.19

#### **COMPLIANCE WITH PRIOR CONDITIONS**

All conditions of approval associated with the original master plan application (File No. 00434337-PMP) and subsequent modifications (File Nos. 00524784-PMP, 00598937-PMP, 00661956-PMPC, 00957990-PMPC) shall remain in full force and effect.

Unless an appeal is filed prior to the expiration of the five-business-day appeal period ending at 5 p.m. on Thursday, October 30, 2025, the approval granted by this letter shall become effective Friday, October 31, 2025.

The stamped-approved plans for Minor Modification 00957990-PMPC are being transmitted electronically along with this letter. Should you wish to obtain a hard copy of the stamped-approved plans, please drop off a set of plans at the Planning Counter. Please note that permits cannot be issued until all fees associated with this application are paid in full.

Should you have any questions regarding this approval, please contact Planning Technician Samantha Zepeda at 949-724-5427 or via email at szepeda@cityofirvine.org.

Sincerely,

Stephanie Frady, AICP

Stephanie Kady

**Director of Community Development** 

#### Enclosures:

1. Approved Project Plans

2. Notice of Exemption dated October 23, 2025

ec: Alyssa Matheus, Planning Manager

Diane Vu, Principal Planner


Files: 00434337-PMP; 00524784-PMP; 00598937-PMP; 00661956-PMPC;

00957990-PMPC


#### **NOTICE OF EXEMPTION**



то: [		State of California Office of Planning & PO Box 3044 Sacramento, CA 95		FROM:	City of Irvine Community Devel PO Box 19575 Irvine, CA 92623- Attn: Samantha		
Σ	◁	County Clerk County of Orange PO Box 238 Santa Ana, CA 927	02		Planning 949-724-5	Technician	
SUBJEC	CT:	Filing of <b>Notice o</b>	f Exemption in comp	liance with Section	on 15062 of the Publi	c Resources Code.	
Project '	Title	e and File No.:	Minor Modification to Area 51 (File No. 009		er Plan for Communit	y Ice Facility in Planning	
Project (include			888 Ridge Valley in F Orange	Planning Area 51	(Great Park), in the	City of Irvine, County of	
Project	Des	cription:	3,303 square feet to	o accommodate	required training s	ommunity ice facility by pace for the Anaheim uction of nine parking	
Approvi	ing	Public Agency:	City of Irvine Director of Communi Development PO Box 19575 Irvine, CA 92623	ty	Approval Date: Resolution No.	October 23, 2025 n/a	
Project /	Арр	olicant:	Rengel & Company A 333 El Camino Real Tustin, CA 92780 Attn: Terrence Sr 714-505-533 tsmith@renger	nith 35			
Exempt (check o			<u>ismitti@rem</u>	geraren.com			
	D E S C	inisterial (Section 2108 eclared Emergency (S mergency Project (Sec tatutory Exemption: ategorical Exemption: eneral Rule Exemptior	ection 21080(b)(3); 15 stion 21080(b)(4); 1520 Section 15301, Class	69(b)(c)) 1 for Existing Fa	<u>cilities</u>		
Reasons Why Project Is Exempt:			Existing Facility by adding 3,30 the existing number an area wher development p	Project is exempt pursuant to CEQA Guidelines Section 15301, Class 1 for Existing Facilities. The project will expand an existing community ice facility by adding 3,303 square feet to provide training space and will not increase the existing number of sheets of ice on-site. The proposed addition is within an area where public services and facilities will allow for the maximum development permissible in the General Plan. The project is minor in nature and will not expand on the existing land use.			
Samant	ha Z	Zepeda, Planning Tech Name and Title	nnician Sas	mantha Z Signature	epsda	October 23, 2025  Date	

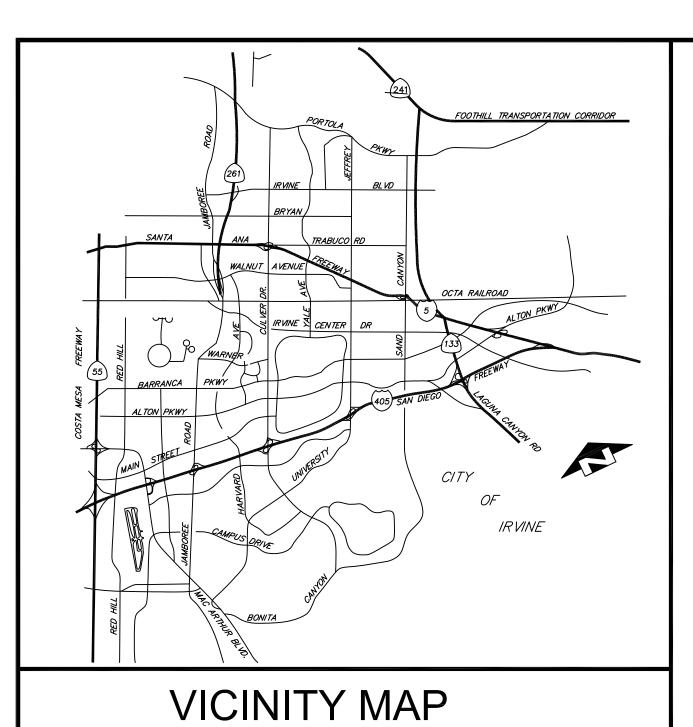

# THE CITY OF IRVINE

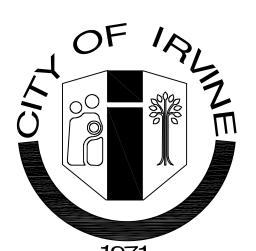

# BUILDING PLANS

INPUT WHERE INDICATED BY INSTRUCTIONS IN BOLD AND BRACKETED BY THE FOLLOWING SYMBOL <>

(VERSION 2022.1 EFFECTIVE JANUARY 2025)

#### PROJECT INFORMATION

**PROJECT LOCATION: 888 RIDGE VALLEY** 

PROJECT DESCRIPTION: THE PROJECT SHALL CONSIST OF CONSTRUCTING A PROPOSED BUILDING ADDITION AT APPROXIMATELY 3,303 S.F. FOR TRAINING/ LOCKER ROOM USE.

SPECIAL CONDITIONS OF LAND USE APPROVAL: SPECIAL CONDITIONS RELATING TO THIS PROJECT ARE ESTABLISHED IN <INSERT TYPE OF PLANNING ACTION AND COMPLETE REFERENCE NUMBER>.

SEE SHEET <INSERT PLAN SHEET NUMBER> UNDER THE HEADING LAND USE CONDITIONS OF APPROVAL FOR COMPLETE CONDITIONS OF APPROVAL.

**USE/OCCUPANCY/FLOOR AREA:** EXISTING OCCUPANCIES: S-2, A-4,B,F,M PROPOSED OCCUPANCIES: A-4

**SQUARE FOOTAGES:** 

	<u>EXISTING</u>	NEW	<u>TOTAL</u>
TOTAL BUILDING SQUARE FOOTAGE:	267,202 S.F.	3,033 S.F.	270,505 S.
BUILDING FOOTPRINT:	212,739 S.F.	3,409 S.F.	216,148 S.
SITE AREA:			649,175 S.
LOT COVERAGE:			
PROPOSED:			339
ALLOWED			65
DEMOLITION AREA:			12,508S

NUMBER OF STORIES: <INSERT NUMBER OF STORIES>

MEZZANINES: <INSERT DESCRIPTION OF MEZZANINES AND STORIES IN WHICH THEY OCCUR. IF NONE, INDICATE "N/A.">

TYPE OF CONSTRUCTION: I-B FULLY SPRINKLERED

FIRE RESISTANCE RATED ASSEMBLIES CONSTRUCTED OR ALTERED IN SCOPE OF WORK: EXTERIOR WALLS: <INSERT YES OR NO. IF YES, DEFINE RATING.>

FIRE WALLS: <INSERT YES OR NO. IF YES, DEFINE RATING.>

FIRE BARRIERS: <INSERT YES OR NO. IF YES, DEFINE RATING.> FIRE PARTITIONS: <INSERT YES OR NO. IF YES, DEFINE RATING.>

HORIZONTAL ASSEMBLIES: <INSERT YES OR NO. IF YES, DEFINE RATING.>

SEE SHEET <INSERT SHEET NUMBERS> FOR FIRE-RESISTANCE RATED ASSEMBLY LEGEND, PROVIDING UNIQUE SYMBOLS FOR EACH RATED ASSEMBLY TYPE/RATING AND CALL-OUTS TO CONSTRUCTION DETAILS DEMONSTRATING COMPLIANCE WITH

**AUTOMATIC FIRE SPRINKLERS:** YES, FULLY SPRINKLERED

AN NFPA 13, AUTOMATIC SPRINKLER SYSTEM SHALL BE PROVIDED UNDER SEPARATE APPROVAL THROUGH THE ORANGE COUNTY FIRE AUTHORITY. SPRINKLERS ARE PROVIDED

TO COMPLY WITH THE CITY OF IRVINE MUNICIPAL CODE SECTION 5-9-401 FOR BUILDING HAVING A GROSS AREA EXCEEDING 5,000 SQUARE FEET.

TO COMPLY WITH THE CITY OF IRVINE MUNICIPAL CODE SECTION 5-9-401 FOR BUILDING HAVING A GROSS AREA EXCEEDING 5,000 SQUARE FEET, AND AS SUBSTITUTION FOR RATED CONSTRUCTION.

TO COMPLY WITH THE CITY OF IRVINE MUNICIPAL CODE SECTION 5-9-401 FOR BUILDING HAVING A GROSS AREA EXCEEDING 5,000

PROVIDE ALTERNATE EXPLANATION INCLUDING ALL RELEVANT CODE REFERENCES

SQUARE FEET, AND TO JUSTIFY AN INCREASE IN HEIGHT /OR AREA (SEE ANALYSIS BELOW)

ALLOWABLE HEIGHT/AREA ANALYSIS (CBC CHAPTER 5):

PER 2022 CBC TABLE 506.2

A-4 OCCUPANCY, 'SM', TYPE 1-B = UNLIMITED S-2 OCCUPANCY, 'SM', TYPE 1-B= 237,000 S.F. 237S.F. > 13,300 S.F. = OK

B OCCUPANCY, 'SM', TYPE 1-B= UNLIMITED F OCCUPANCY, 'SM', TYPE 1-B= UNLIMITED M OCCUPANCY, 'SM', TYPE 1-B= UNLIMITED

CALIFORNIA ENERGY EFFICIENCY CODE

CALIFORNIA GREEN BUILDING STANDARDS CODE

PARKING SUMMARY:

REQUIRED PARKING: 665 STALLS TOTAL PARKING PROVIDED: 654 STALLS VAN ACCESSIBLE PARKING PROVIDED: 3 STALLS STANDARD ACCESSIBLE PARKING PROVIDED: 11 STALLS APPLICABLE STATE CODES (WITH CITY OF IRVINE AMENDMENTS): CALIFORNIA BUILDING CODE CALIFORNIA ELECTRIC CODE CALIFORNIA MECHANICAL CODE CALIFORNIA PLUMBING CODE

### WATER CONSERVING PLMB. FIXTURE VERIFICATION/RETROFIT

BUILDINGS FOR WHICH AN INITIAL FINAL INSPECTION WAS RECEIVED ON OR BEFORE JANUARY 1, 1994 SHALL COMPLY WITH THE CITY OF IRVINE'S INFORMATION BULLETIN # 321. WAS THE INITIAL FINAL INSPECTION ON THE PROPERTY UNDERGOING THE PROPOSED TENANT IMPROVEMENT RECEIVED PRIOR TO JANUARY 1, 1994: <INSERT YES OR NO>

#### CALIFORNIA GREEN BUILDING STANDARDS CODE

PROVISIONS OF THE CALIFORNIA GREEN BUILDING STANDARDS CODE APPLY TO ALL NEW LOW-RISE RESIDENTIAL BUILDINGS (THREE STORIES AND LESS INCLUDING HOTELS AND MOTELS) AND ALL NON-RESIDENTIAL TENANT IMPROVEMENT WITH VALUATION EQUAL OR GREATER THAN \$200,000 AND ADDITIONS EQUAL OR GREATER THAN 1,000 SQUARE FEET.

SEE SHEET<INSERT PLAN SHEET NUMBER OR INDICATE N/A> FOR COMPLETED CITY OF IRVINE GREEN BUILDING STANDARDS

## CALIFORNIA BUILDING ENERGY EFFICIENCY STANDARDS

PROVISIONS OF THE CALIFORNIA BUILDING ENERGY EFFICIENCY STANDARD APPLY TO THIS PROJECT SEE SHEET <INSERT SHEET NUMBER> FOR COMPLETE COMPLIANCE DOCUMENTATION.

#### SPECIAL INSPECTION AND STRUCTURAL OBSERVATION

THIS PROJECT IS SUBJECT TO BOTH SPECIAL INSPECTIONS AND STRUCTURAL OBSERVATION PER CALIFORNIA BUILDING CODE (CBC) CHAPTER 17 AND SHALL FOLLOW THE REQUIREMENTS AS DEFINED IN CITY OF IRVINE INFORMATION BULLETINS NO. 278 AND 251.

SEE SHEET <INSERT PLAN SHEET NUMBER> FOR COMPLETED PROJECT SPECIFIC CITY OF IRVINE SPECIAL INSPECTION PROGRAM

SEE SHEET <INSERT PLAN SHEET NUMBER> FOR COMPLETED PROJECT SPECIFIC CITY OF IRVINE SPECIAL OBSERVATION

#### CITY OF IRVINE MUNICIPAL CODE

[NOTE: COMPLETE IMC TEXT IS AVAILABLE ON THE INTERNET AT WWW.MUNICODE.COM] THE DESIGN AND CONSTRUCTION OF THIS PROJECT SHALL COMPLY WITH ALL APPLICABLE IRVINE MUNICIPAL CODE PROVISIONS INCLUDING BUT NOT LIMITED TO:

CONSTRUCTION WORK HOURS [IMC SECT. 6-8-205] MON-FRI 7 AM TO 7 PM SAT 9 AM TO 6 PM

NO WORK ON SUNDAYS OR FEDERAL HOLIDAYS

SECURITY DESIGN STANDARDS [IMC SECT. 5-9-517 AND 5-9-528]

#### **OFF-SITE FABRICATION**

ALL OFF-SITE FABRICATION OF STRUCTURAL STEEL COMPONENTS INCLUDING STEEL STAIRS AND PRE-CAST CONCRETE SHALL BE DONE IN AN APPROVED FABRICATOR SHOP AS REQUIRED BY CITY OF IRVINE INFORMATION BULLETIN NO. 311. SEE BULLETIN FOR DETAILS AND REQUIRED DOCUMENTATION REQUIRED AT THE RECEIPT OF ANY SHIPMENT OF OFF-SITE FABRICATED ITEMS.

#### PRE-CONSTRUCTION MEETING REQUIREMENT

SEE SHEET</NSERT PLAN SHEET NUMBER> FOR APPLICABLE COMPLETED SECURITY CODE PROVISIONS

ALL CONSTRUCTION PROJECTS INVOLVING ADDITIONS TO NON-RESIDENTIAL STRUCTURES AND PARKING LOT MODIFICATIONS SHALL NOT COMMENCE UNTIL A PRE-CONSTRUCTION MEETING HAS BEEN HELD. THESE MEETINGS, WHILE NOT REQUIRED BY CITY CODE FOR TENANT IMPROVEMENTS NOT ADDING AREA, ARE BENEFICIAL FOR MAJOR TENANT IMPROVEMENTS TO SCHEDULE A PRE-CONSTRUCTION MEETING CONTACT COMMERCIAL BUILDING INSPECTOR SUPERVISOR AT (949) 724-6139 FOR BUILDING INSPECTIONS AND GRADING INSPECTOR SUPERVISOR AT (949) 724-6329 FOR PARKING LOT MODIFICATIONS INSPECTIONS.

#### DEFERRED SUBMITTALS

THIS PROJECT HAS BEEN PERMITTED WITHOUT REVIEW AND/OR APPROVAL OF THE FOLLOWING DEFERRED SUBMITTALS. PLANS APPROVED BY THE CITY SHALL BE OBTAINED FOR EACH DEFERRED ITEM LISTED BELOW PRIOR TO COMMENCING ANY WORK WITHIN THE SCOPE OF SUCH DEFERRAL. DEFERRALS MUST BE REVIEWED AND ACCEPTED BY THE ARCHITECT OR ENGINEER OF RECORD PRIOR TO SUBMITTING FOR REVIEW WITH THE CITY.

<INSERT COMPREHENSIVE LIST OF DEFERRED SUBMITTALS USING SEPARATE LINE PER ITEM>

#### **ADDITIONS AND ALTERATIONS:**

PRIOR TO USE, OCCUPANCY OR FINAL INSPECTION, EXISTING OR RETROFITTED ADDRESSING MEETING THE HEIGHT, CONTRAST AND FONT REQUIREMENTS OF SECTION 5-9-517 ITEM L OF THE CITY OF IRVINE MUNICIPAL CODE SHALL BE VERIFIED BY THE CITY INSPECTOR.

CONTRACTOR SHALL RESTORE ALL ORIGINAL AND REQUIRED FIRE PROTECTION ON STRUCTURAL ELEMENTS AND RATED ASSEMBLIES.

PRIOR TO FINAL INSPECTION, THE OPENING FORCE FOR DOORS SERVING THE DESIGNATED ACCESSIBLE PATH OF TRAVEL SHALL BE VERIFIED TO COMPLY WITH CBC 11B-404.2.9. POWERED EXTERIOR DOORS, PER EXCEPTION 2, SERVING A SPACE WITH AN OCCUPANCY OF 150 OR MORE ARE REQUIRED TO BE EQUIPPED WITH BACK-UP POWER.

#### **FIRE DEPARTMENT NOTES:**

AND FINAL PLACEMENT IS SUBJECT TO APPROVAL.

- FOR ASSISTANCE WITH FIRE-RELATED PLAN REVIEW ISSUES OR TECHNICAL QUESTIONS, PLEASE CALL (714) 573-6108. FOR FIRE-RELATED INSPECTION QUESTIONS OR ISSUES, PLEASE CONTACT YOUR OCFA INSPECTOR DIRECTLY OR OCFA INSPECTION SCHEDULING AT (714) 573-6150 FOR ASSISTANCE.
- 2. THE PROJECT SHALL COMPLY WITH THE CURRENTLY ADOPTED CALIFORNIA BUILDING CODE, CALIFORNIA FIRE CODE, AND OTHER CODES, STANDARDS, REGULATIONS AND REQUIREMENTS AS ENFORCED BY THE ORANGE COUNTY FIRE AUTHORITY. APPROVAL OF THESE PLANS SHALL NOT PERMIT THE VIOLATION OF ANY CODE OR LAW.
- 3. FOR PROJECTS INVOLVING NEW STRUCTURES, ADDITIONS TO EXISTING STRUCTURES, INSTALLATION OF GATES/WALLS/FENCES, OR ALTERATION OF VEHICULAR ACCESS, A FIRE MASTER PLAN SHALL BE SUBMITTED TO AND APPROVED BY THE OCFA PRIOR TO SUBMITTAL OF ARCHITECTURAL PLANS. AN APPROVED FIRE MASTER PLAN SHALL BE SUBMITTED WITH THE ARCHITECTURAL PLANS.
- 4. ALL WEATHER FIRE ACCESS ROADS SHALL BE APPROVED BY THE OCFA AND BE IN PLACE BEFORE ANY COMBUSTIBLE MATERIALS ARE PLACED ON THE SITE. ACCESS ROADS SHALL BE MAINTAINED CLEAR OF OBSTRUCTIONS DURING AND AFTER CONSTRUCTION.
- ADDRESS NUMBERS SHALL BE PROVIDED FOR ALL NEW AND EXISTING BUILDINGS, BE A MINIMUM SIX INCHES HIGH, CONTRAST WITH THEIR BACKGROUND, AND BE PLAINLY VISIBLE FROM THE ROADWAY THE BUILDING IS ADDRESSED ON OR AS OTHERWISE ALLOWED BY OCFA GUIDELINE B-09.

6. BUILDINGS UNDER CONSTRUCTION OR DEMOLITION SHALL CONFORM TO CFC CHAPTER 33. NO SMOKING OR COOKING IS

ALLOWED IN STRUCTURES WHERE COMBUSTIBLE MATERIALS ARE EXPOSED OR WITHIN 25' OF COMBUSTIBLE MATERIALS

7. LOCATIONS AND CLASSIFICATIONS OF EXTINGUISHERS SHALL BE IN ACCORDANCE WITH THE CFC AND CCR TITLE 19. AT LEAST ONE EXTINGUISHER SHALL BE PROVIDED DURING CONSTRUCTION ON EACH FLOOR AT EACH STAIRWAY, IN EACH STORAGE AND CONSTRUCTION SHED, IN LOCATIONS WHERE FLAMMABLE OR COMBUSTIBLE LIQUIDS ARE STORED OR USED, OR WHERE SIMILAR HAZARDS ARE PRESENT. BEFORE FINAL OCCUPANCY, AT LEAST ONE 2A:10B:C EXTINGUISHER SHALL BE PROVIDED SO THAT NO POINT IS MORE THAN 75' TRAVEL DISTANCE FROM THE EXTINGUISHER. EXTINGUISHERS SHALL BE LOCATED ALONG THE PATH OF EGRESS TRAVEL AND IN A READILY VISIBLE AND ACCESSIBLE LOCATION, WITH THE BOTTOM

STORAGE AREAS. CUTTING, WELDING, OR OTHER HOT WORK SHALL BE IN CONFORMANCE WITH CFC CHAPTER 35.

8. WALL, FLOOR AND CEILING FINISHES AND DECORATIVE MATERIALS SHALL NOT EXCEED THE FLAME SPREAD CLASSIFICATIONS IN CBC/CFC CHAPTER 8. DECORATIVE MATERIALS SHALL BE PROPERLY TREATED BY A PRODUCT OR PROCESS APPROVED BY THE STATE FIRE MARSHAL. SUCH ITEMS SHALL BE APPROVED AND INSPECTED PRIOR TO

OF THE EXTINGUISHER AT LEAST 4" ABOVE THE FLOOR. ADDITIONAL EXTINGUISHERS MAY BE REQUIRED BY THE INSPECTOR

- 9. KNOX BOXES/KEY CABINETS SHALL BE PROVIDED FOR ALL POOL ENCLOSURES, GATES IN THE PATH OF FIREFIGHTER TRAVEL TO STRUCTURES, SECURED PARKING LEVELS, DOORS GIVING ACCESS TO ALARM PANELS AND/OR ANNUNCIATORS, AND ANY OTHER STRUCTURES OR AREAS WHERE IMMEDIATE ACCESS IS REQUIRED OR IS UNDULY DIFFICULT.
- 10. DUMPSTERS AND TRASH CONTAINERS EXCEEDING 1.5 CUBIC YARDS SHALL NOT BE STORED IN BUILDINGS OR PLACED WITHIN 5 FEET OF COMBUSTIBLE WALLS, OPENINGS OR COMBUSTIBLE ROOF EAVE LINES UNLESS PROTECTED BY AN APPROVED SPRINKLER SYSTEM OR LOCATED IN A TYPE I OR IIA STRUCTURE SEPARATED BY 10 FEET FROM OTHER STRUCTURES. CONTAINERS LARGER THAN 1 CUBIC YARD SHALL BE OF NON- OR LIMITED-COMBUSTIBLE MATERIALS OR SIMILARLY PROTECTED OR SEPARATED. CFC 304.3
- 11. EXITS, EXIT SIGNS, FIRE ALARM PANELS, HOSE CABINETS, FIRE EXTINGUISHER LOCATIONS, AND STANDPIPE CONNECTIONS SHALL NOT BE CONCEALED BY CURTAINS, MIRRORS, OR OTHER DECORATIVE MATERIAL. THE EGRESS PATH SHALL REMAIN FREE AND CLEAR OF ALL OBSTRUCTIONS AT ALL TIMES. NO STORAGE IS PERMITTED IN AISLES.
- 12. EXIT DOORS SHALL BE OPENABLE FROM THE INSIDE WITHOUT THE USE OF A KEY OR ANY SPECIAL KNOWLEDGE OR EFFORT. DOORS SHALL NOT BE PROVIDED WITH THUMB-TURN LOCKS OR DEADBOLTS THAT DO NOT UNLATCH IN TANDEM WITH THE NORMAL OPERATING LEVER. RATED DOORS SHALL BE SELF-CLOSING AND LATCHING; SUCH DOORS SHALL NOT BE EQUIPPED WITH DOOR STOPS OR OTHERWISE PROPPED OPEN.
- 13. SPRINKLER AND ALARM SYSTEMS SHALL BE PROVIDED WHEN REQUIRED BY CBC/CFC CHAPTER 9 AND LOCAL ORDINANCE. IN STRUCTURES OF UNDETERMINED USE, THE MINIMUM FIRE SPRINKLER DESIGN DENSITY REQUIRED SHALL BE ORDINARY HAZARD (GROUP 2) WITH A DESIGN AREA OF 3000 SQUARE FEET.

- EXISTING SPRINKLER AND ALARM SYSTEMS IN SPACES UNDERGOING REMODELING SHALL BE EVALUATED BY A LICENSED CONTRACTOR KNOWLEDGEABLE IN SUCH SYSTEMS TO DETERMINE WHETHER CHANGES WILL BE NECESSARY TO MAINTAIN THESE SYSTEMS IN CONFORMANCE WITH APPLICABLE STANDARDS. IF MODIFICATIONS ARE NECESSARY, PLANS SHALL BE SUBMITTED TO THE OCFA FOR REVIEW AND APPROVAL PRIOR TO MODIFICATION OF THE SYSTEM. SPRINKLER AND ALARM
- WHERE COMMERCIAL-TYPE FOOD HEATING OR COOKING EQUIPMENT THAT PRODUCES GREASE-LADEN VAPORS IS PRESENT, AN AUTOMATIC EXTINGUISHING SYSTEM SHALL BE PROVIDED AND SHALL COMPLY WITH CFC, CMC, AND NFPA 17A. REVIEW AND APPROVAL OF A HOOD AND DUCT EXTINGUISHING SYSTEM PLAN BY THE OCFA IS REQUIRED PRIOR TO INSTALLATION, MODIFICATION, REARRANGEMENT, OR USE OF COOKING EQUIPMENT
- 16. HAZARDOUS MATERIALS EQUIPMENT, PROCESSES, STORAGE, DISPENSING, OR USE SHALL COMPLY WITH CBC AND CFC REGULATIONS AND SHALL BE REVIEWED AND APPROVED BY THE OCFA PRIOR TO SUCH MATERIALS OR EQUIPMENT BEING
- 17. STORAGE AREAS GREATER THAN 500 SQ.FT. WITH HIGH HAZARD MATERIALS STORED HIGHER THAN SIX FEET AND OTHER MATERIALS STORED HIGHER THAN TWELVE FEET ARE NOT PERMITTED WITHOUT FIRST SUBMITTING PLANS TO AND OBTAINING APPROVAL FROM THE OCFA.
- A NEW HVAC UNIT EXCEEDING A 2,000 CFM CAPACITY SHALL BE PROVIDED WITH A DUCT SMOKE DETECTOR. THIS DETECTOR SHALL SHUT DOWN ONLY THE AFFECTED INDIVIDUAL HVAC UNIT UPON SMOKE DETECTION. THIS DETECTOR MUST ALSO BE INTERFACED TO AN EXISTING FIRE ALARM SYSTEM. THE DETECTOR SHALL ONLY PROVIDE A SUPERVISORY SIGNAL AT THE FIRE ALARM PANEL UPON SMOKE DETECTION.

#### STORM WATER POLLUTION PREVENTION NOTES

STORMWATER POLLUTION PREVENTION DEVICES AND PRACTICES SHALL BE INSTALLED AND/OR INSTITUTED AS NECESSARY TO ENSURE COMPLIANCE TO THE CITY OF IRVINE WATER QUALITY STANDARDS CONTAINED IN CHAPTER 3. WATER, OF DIVISION 8 OF TITLE 6 OF THE IRVINE MUNICIPAL CODE AND ANY EROSION CONTROL PLAN ASSOCIATED WITH THIS PROJECT. ALL SUCH DEVICES AND PRACTICES SHALL BE MAINTAINED, INSPECTED AND/OR MONITORED TO ENSURE ADEQUACY AND PROPER FUNCTION THROUGHOUT THE DURATION OF THE CONSTRUCTION PROJECT.

COMPLIANCE TO THE WATER QUALITY STANDARDS AND ANY EROSION AND SEDIMENT CONTROL PLAN ASSOCIATED WITH THIS PROJECT INCLUDES, BUT IS NOT LIMITED TO THE FOLLOWING REQUIREMENTS:

- 1. AN EFFECTIVE COMBINATION OF EROSION AND SEDIMENT CONTROL MEASURES (BMPs) SHALL BE IMPLEMENTED TO PROTECT THE EXPOSED PORTIONS OF THE SITE FROM EROSION AND TO PREVENT SEDIMENT DISCHARGES.
- 2. SEDIMENTS AND OTHER POLLUTANTS SHALL BE RETAINED ON SITE UNTIL PROPERLY DISPOSED OF, AND MAY NOT BE TRANSPORTED FROM THE SITE VIA SHEET FLOW, SWALES, AREA DRAINS, NATURAL DRAINAGE COURSES OR WIND.

3. STOCKPILES OF EARTH AND OTHER CONSTRUCTION-RELATED MATERIALS SHALL BE PROTECTED FROM BEING

- TRANSPORTED FROM THE SITE BY THE FORCES OF WIND AND WATER FLOW. 4. FUELS, OILS, SOLVENTS, AND OTHER TOXIC MATERIALS SHALL BE STORED IN ACCORDANCE WITH THEIR LISTING AND ARE NOT TO CONTAMINATE THE SOIL AND SURFACE WATERS. ALL APPROVED STORAGE CONTAINERS ARE TO BE PROTECTED
- FROM THE WEATHER. SPILLS MUST BE CLEANED UP IMMEDIATELY AND DISPOSED OF IN A PROPER MANNER. SPILLS MAY NOT BE WASHED INTO THE DRAINAGE SYSTEM, NOR BE ALLOWED TO SETTLE OR INFILTRATE INTO SOIL 5. EXCESS OR WASTE CONCRETE MAY NOT BE WASHED INTO THE PUBLIC WAY OR ANY OTHER DRAINAGE

SYSTEM. PROVISIONS SHALL BE MADE TO RETAIN CONCRETE WASTES ON SITE UNTIL THEY CAN BE DISPOSED OF AS SOLID

- 6. TRASH AND CONSTRUCTION SOLID WASTES SHALL BE DEPOSITED INTO A COVERED RECEPTACLE TO PREVENT CONTAMINATION OF RAINWATER AND DISPERSAL BY WIND.
- 7. SEDIMENTS AND OTHER MATERIALS MAY NOT BE TRACKED FROM THE SITE BY VEHICULAR TRAFFIC. THE CONSTRUCTION ENTRANCE ROADWAYS MUST BE STABILIZED SO AS TO INHIBIT SEDIMENTS FROM BEING DEPOSITED INTO THE PUBLIC WAY. ACCIDENTAL DEPOSITS SHALL BE SWEPT UP IMMEDIATELY AND MAY NOT BE WASHED DOWN BY RAIN OR OTHER
- 8. STORMWATER POLLUTION PREVENTION DEVICES AND/OR PRACTICES SHALL BE MODIFIED AS NEEDED AS THE PROJECT PROGRESSES TO ENSURE EFFECTIVENESS.

## PARKING LOT MODIFICATION INSPECTION NOTES

- PRIOR TO THE START OF ANY WORK, A PRE-GRADING MEETING AT THE SITE IS REQUIRED WITH THE OWNER, CONTRACTOR, GEOTECHNICAL ENGINEER (IF APPLICABLE), OR THEIR AGENTS, AND THE CITY GRADING INSPECTOR. THE PERMITTEE SHALL CONTACT GRADING INSPECTION TO SCHEDULE (949) 724-6329.
- 2. THE REQUIREMENTS FOR DEPUTY INSPECTION AND PERMIT CLOSE-OUT DOCUMENTATION WILL BE DETERMINED BY THE CITY GRADING INSPECTOR AT THE PRE-GRADE MEETING. THE REQUIRED GRADING INSPECTIONS WILL BE DEFINED AT THE
- 3. ALL WORK SHALL BE IN ACCORDANCE WITH THE LATEST ADOPTED EDITION OF A. THE IRVINE GRADING AND EXCAVATION REGULATIONS AND GRADING MANUAL
- B. THE CITY OF IRVINE STANDARD PLANS

C. SPECIAL REQUIREMENTS OF THE GRADING OR PARKING LOT MODIFICATION PERMIT

- E. STANDARD SPECIFICATION FOR PUBLIC WORKS CONSTRUCTION (GREEN BOOK)
- F. MANUAL OF UNIFORM TRAFFIC CONTROL DEVICES (MUCTD) G. THE CITY OF IRVINE CONSTRUCTION SITE SECURITY ORDINANCE.

UPON THE COMMUNITY (IRVINE MUNICIPAL CODE SEC. 6-8-205).

- 4. CONSTRUCTION OPERATIONS SHALL OCCUR ONLY BETWEEN THE HOURS OF 7:00 A.M. AND 7:00 P.M., MONDAY THROUGH FRIDAY, AND BETWEEN THE HOURS OF 9:00 A.M. AND 6:00 P.M. SATURDAYS. NO CONSTRUCTION ACTIVITIES SHALL BE PERMITTED OUTSIDE OF THESE PERMITTED HOURS OR ON SUNDAYS AND FEDERAL HOLIDAYS, UNLESS A TEMPORARY WAIVER HAS BEEN GRANTED BY THE CHIEF BUILDING OFFICIAL. ANY WAIVERS SHALL TAKE INTO ACCOUNT THE IMPACT
- 5. ACCESSIBLE STALLS AND PATHS OF TRAVEL SHALL BE TEMPORARILY RELOCATED, AS NEEDED, TO MAINTAIN COMPLIANT ACCESSIBILITY, TO BE DETERMINED AT THE PRE-GRADING MEETING TO THE SATISFACTION OF THE GRADING INSPECTOR.
- ALL ACCESSIBLE STALL STRIPING AND SIGNAGE SHALL BE PER THE CURRENT EDITION OF THE CALIFORNIA BUILDING CODE. ALL STANDARD PARKING STALL STRIPING SHALL BE PER CITY OF IRVINE STANDARD PLAN NO. 411

#### **EPA RENOVATION, REPAIR, AND PAINTING (RRP) RULE:** EPA REGULATIONS REQUIRE THAT ANY CONTRACTOR OR MAINTENANCE STAFF WHO DISTURBS LEAD-BASED PAINT IN A PRE-1978

RESIDENCE OR CHILD-CARE FACILITY MUST BE LEAD-SAFE CERTIFIED AND TRAINED IN LEAD-SAFE WORK PRACTICES.

# **RECYCLING:**

CONSTRUCTION WASTE MATERIAL SHALL BE RECYCLED PER APPROVED CONSTRUCTION WASTE REDUCTION COMPLIANCE

## SOUTH COAST AIR QUALITY MANAGEMENT DISTRICT ADVISORY:

SOUTH COAST AIR QUALITY MANAGEMENT DISTRICT (SCAQMD) RULE 1403 GOVERNS WORK PRACTICE REQUIREMENTS FOR ASBESTOS IN ALL RENOVATION AND DEMOLITION ACTIVITIES. PLEASE REFER TO RULE 1403 (HTTP://WWW.AQMD.GOV/DOCS/DEFAULT-SOURCE/RULE-BOOK/REG-XIV/RULE-1403.PDF) FOR ALL CURRENT REQUIREMENTS.

CALIFORNIA HEALTH AND SAFETY CODE 19827.5 REQUIRES THAT EVIDENCE OF DEMOLITION NOTIFICATION SUBMITTED TO THE SOUTH COAST AQMD BE PROVIDED TO CITY OF IRVINE BUILDING AND SAFETY PRIOR TO THE ISSUANCE OF ANY BUILDING PERMIT INCLUDING DEMOLITION WORK.



# **LOCATION MAP**

#### ACCESSIBILITY COMPLIANCE:

CALIFORNIA BUILDING CODE, CHAPTER 11B REQUIRES COMPLIANCE WITH ALL PATH OF TRAVEL REQUIREMENTS. IS THE

WHEN USING CODE EXCEPTIONS ONLY, REFER TO SHEET FOR JUSTIFICATION

PROFESSIONAL OF RECORD USING CODE EXCEPTIONS FOR COMPLIANCES YES

#### SHEET INDEX:

SEE SHEET T100 FOR SHEET INDEX.

# City of Irvine

BY Samantha Zepeda

CASE # 00957990-PMPC

# **APPROVED**

SHEET TI2


PERMIT :00957990-PMPC

PLAN CHECK:

**ENCLOSURE 2** 

# GREAT PARKICE

# TENANT IMPROVEMENTS 888 • RIDGE VALLEY • CALIFORNIA • 92618

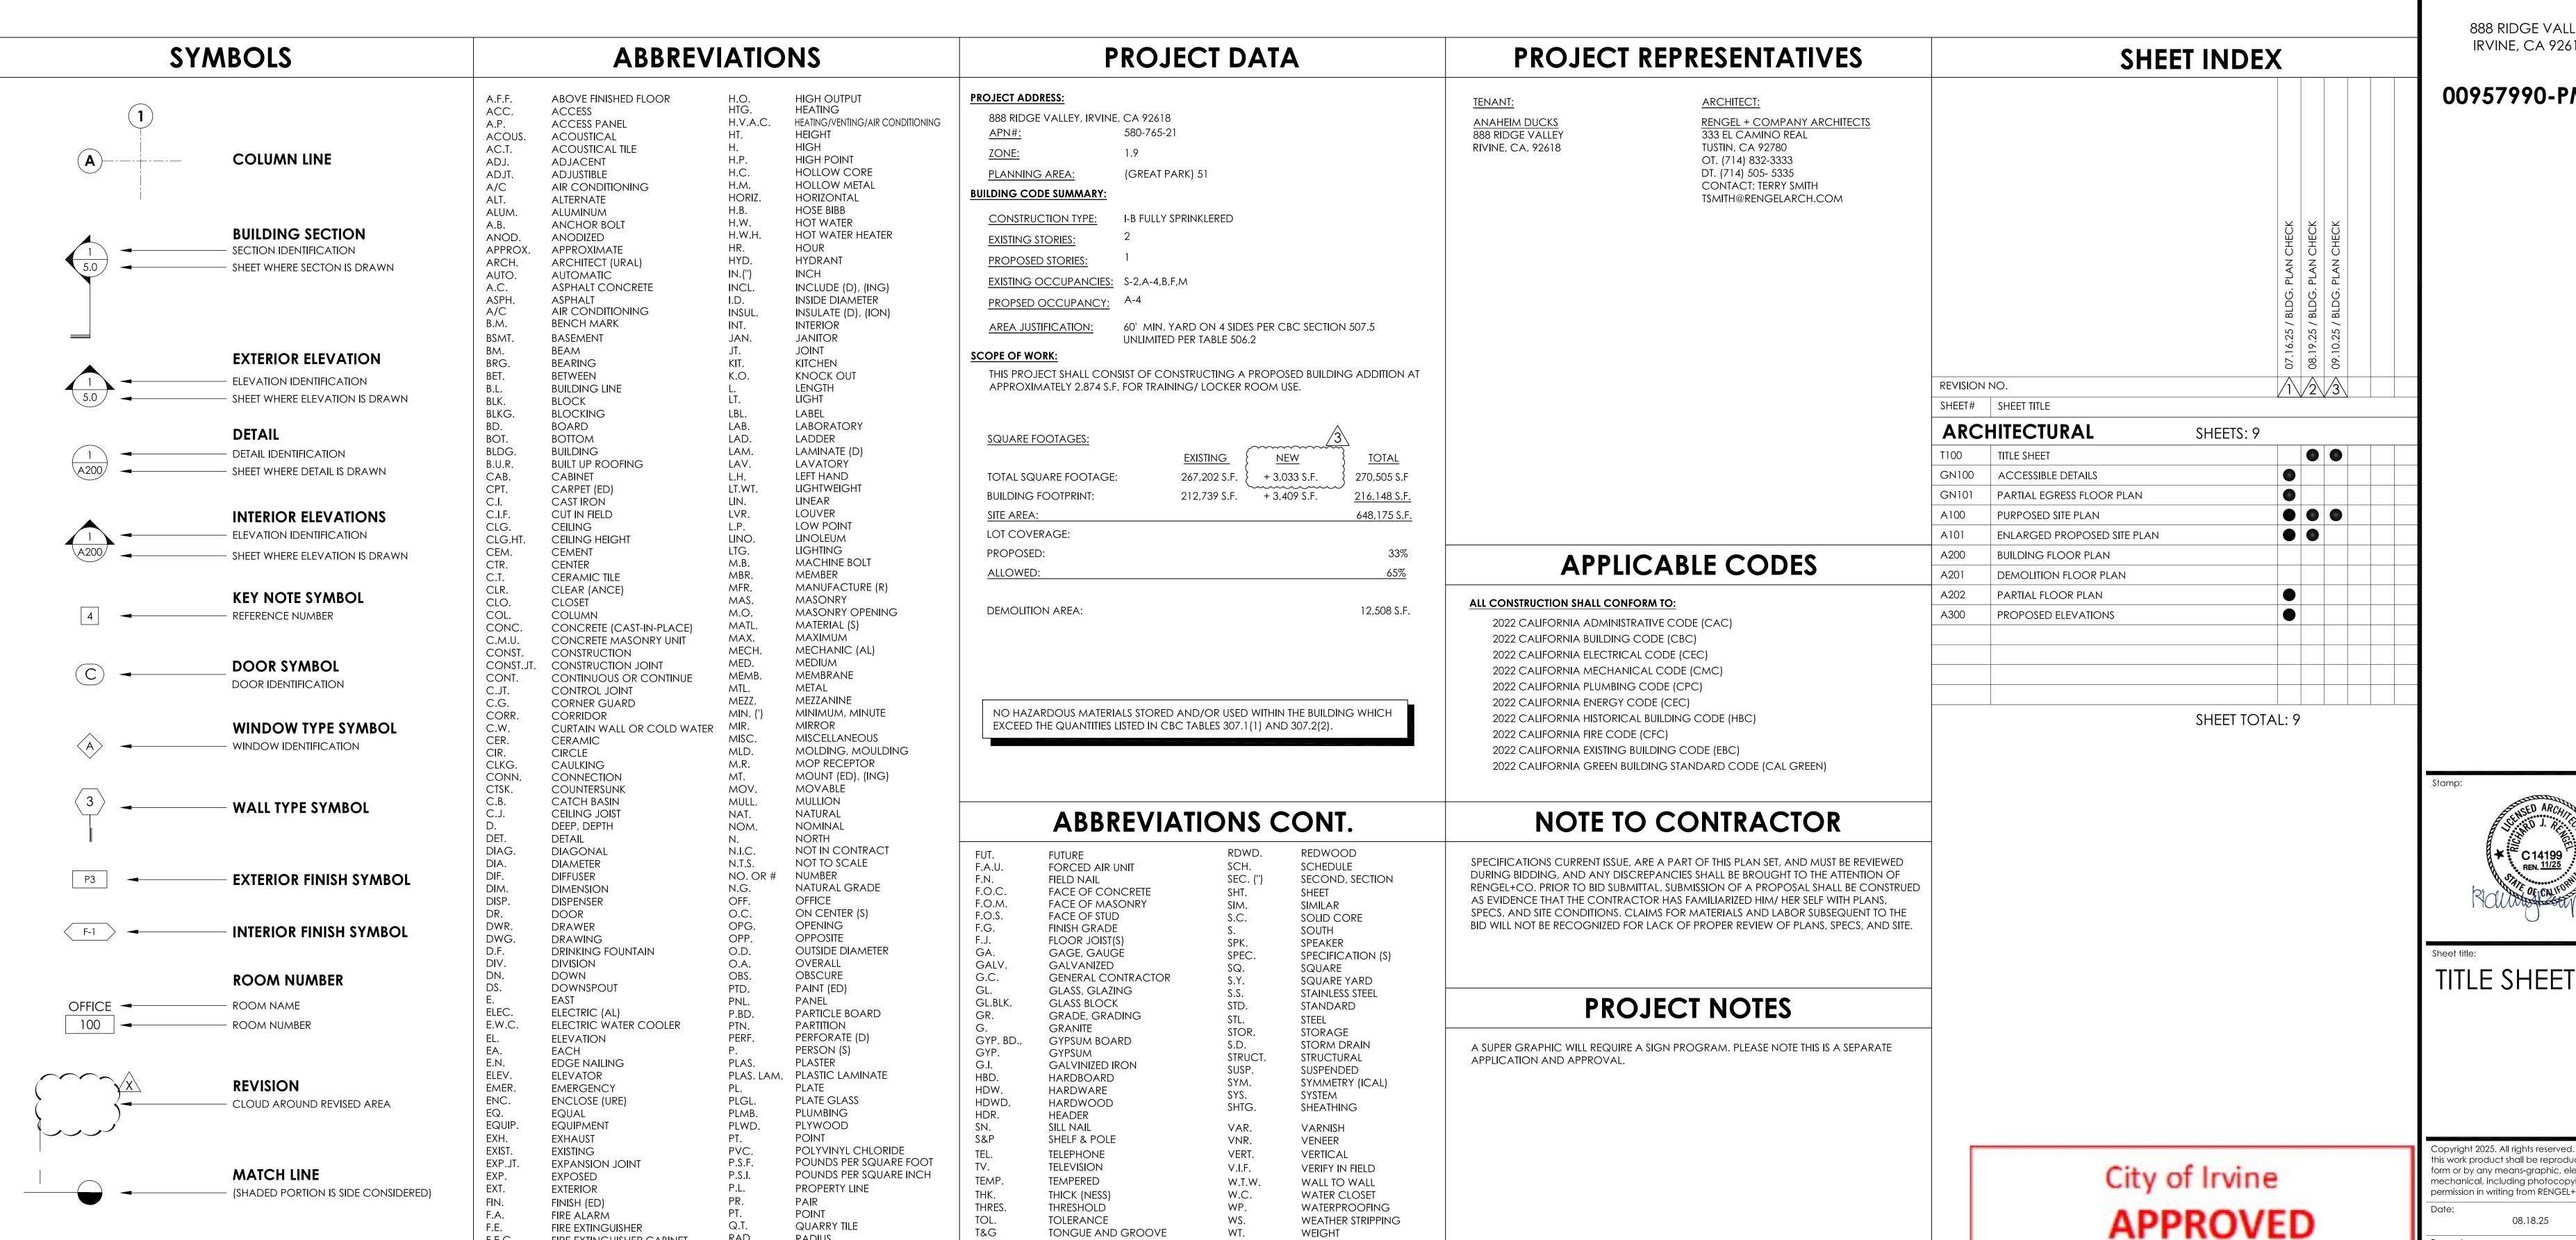

WEATHER STRIPPING

WELDED WIRE FABRIC

WEST, WIDE, WIDTH

WINDOW

**WIRED GLASS** 

WORKING POINT

WATER HEATER

WATER RESISTANT

GYPSUM BOARD

WIRE MESH

WITHOUT

WOOD

WSCT.

W.R.G.B.

**TOLERANCE** 

TOP OF CURB

TOP OF SLAB

TOP OF STEEL

TOP OF WALL

TYPICAL

**TRANSFORMER** 

TOP OF BEAM

TOP PLATE

UNFINISHED

T.O.STL

T.O.W.

TOP OF PARAPET

TONGUE AND GROOVE

UNLESS OTHERWISE NOTED

VAPOR BARRIER (RETARDER)

**QUARRY TILE** 

**RECEPTACLE** 

REINFORCE (D), (ING)

REVISION (S), REVISED

REFERENCE

REGISTER

RESILIENT

RETURN AIR

RIGHT HAND

**ROOF DRAIN** 

ROUGH OPENING

RETURN

RADIUS

RAD.

RESIL.

R.D.

R.O.

FIRE EXTINGUISHER

FIRE HOSE STATION

**FIREPROOFING** 

FIRE-RESISTANT

FLOOR (ING)

FLOOR DRAIN

FLUORESCEN<sup>T</sup>

**FOUNDATION** 

FURRED (ING)

FULL SIZE

FRESH AIR INTAKE

FIRE EXTINGUISHER CABINET

FIRE-PROOF-SELF-CLOSING

F.E.C.

F.H.S.

F.P.S.C.

FLR

F.D.

FLUOR.

FT. (')

FTG.

FND.

F.A.I.

F.S.

FURR.

DATUM POINT

NORTH ARROW

**NORTH** 

333 El Camino Real, Tustin, California 92780 O+ 714.832.3333


www.rengelarch.com

Project name:

**GREAT PARK ICE** 

888 RIDGE VALLEY IRVINE, CA 92618

00957990-PMPC

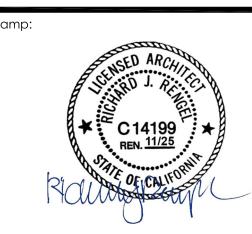

Copyright 2025. All rights reserved. No part of this work product shall be reproduced in any form or by any means-graphic, electronic or mechanical, including photocopying, without permission in writing from RENGEL+CO.

08.18.25 R.C.A. Project #:

BY Samantha Zepeda


DATE 10/23/2025


CASE # 00957990-PMPC


202524 Projects/Ducks/Irvine/Great Park Ice

Locker Room 2025/ CDs

T100

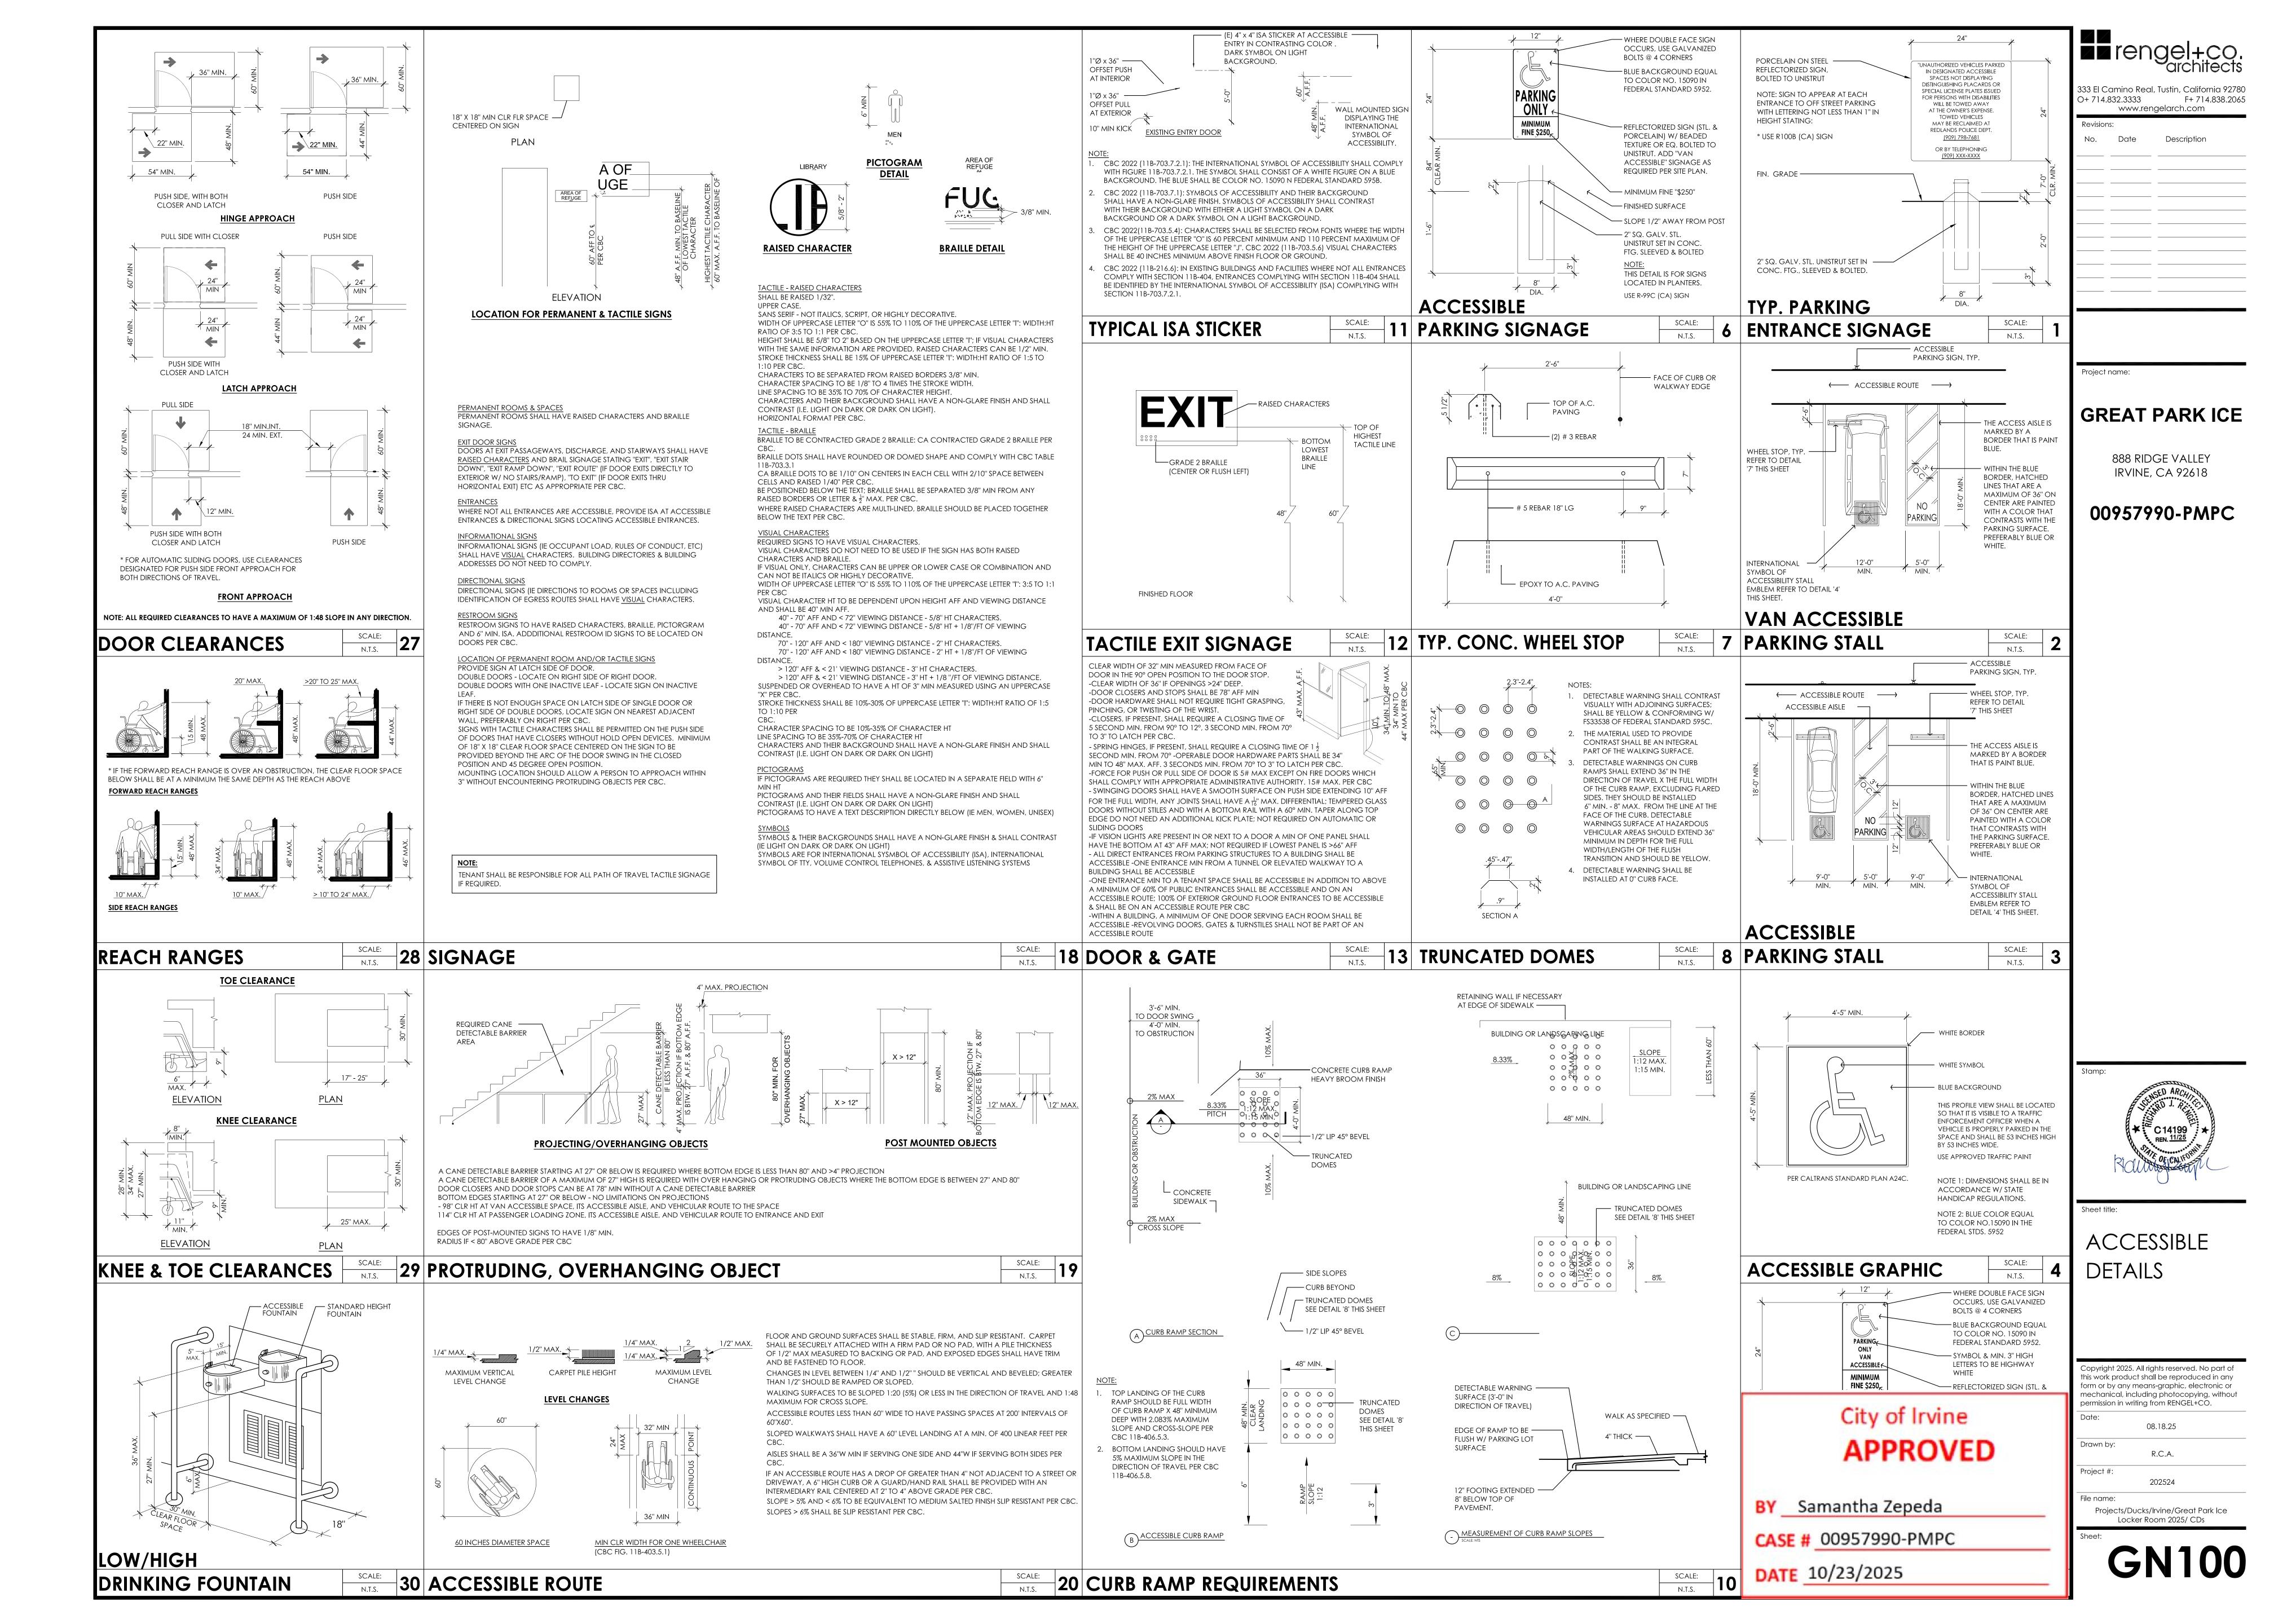

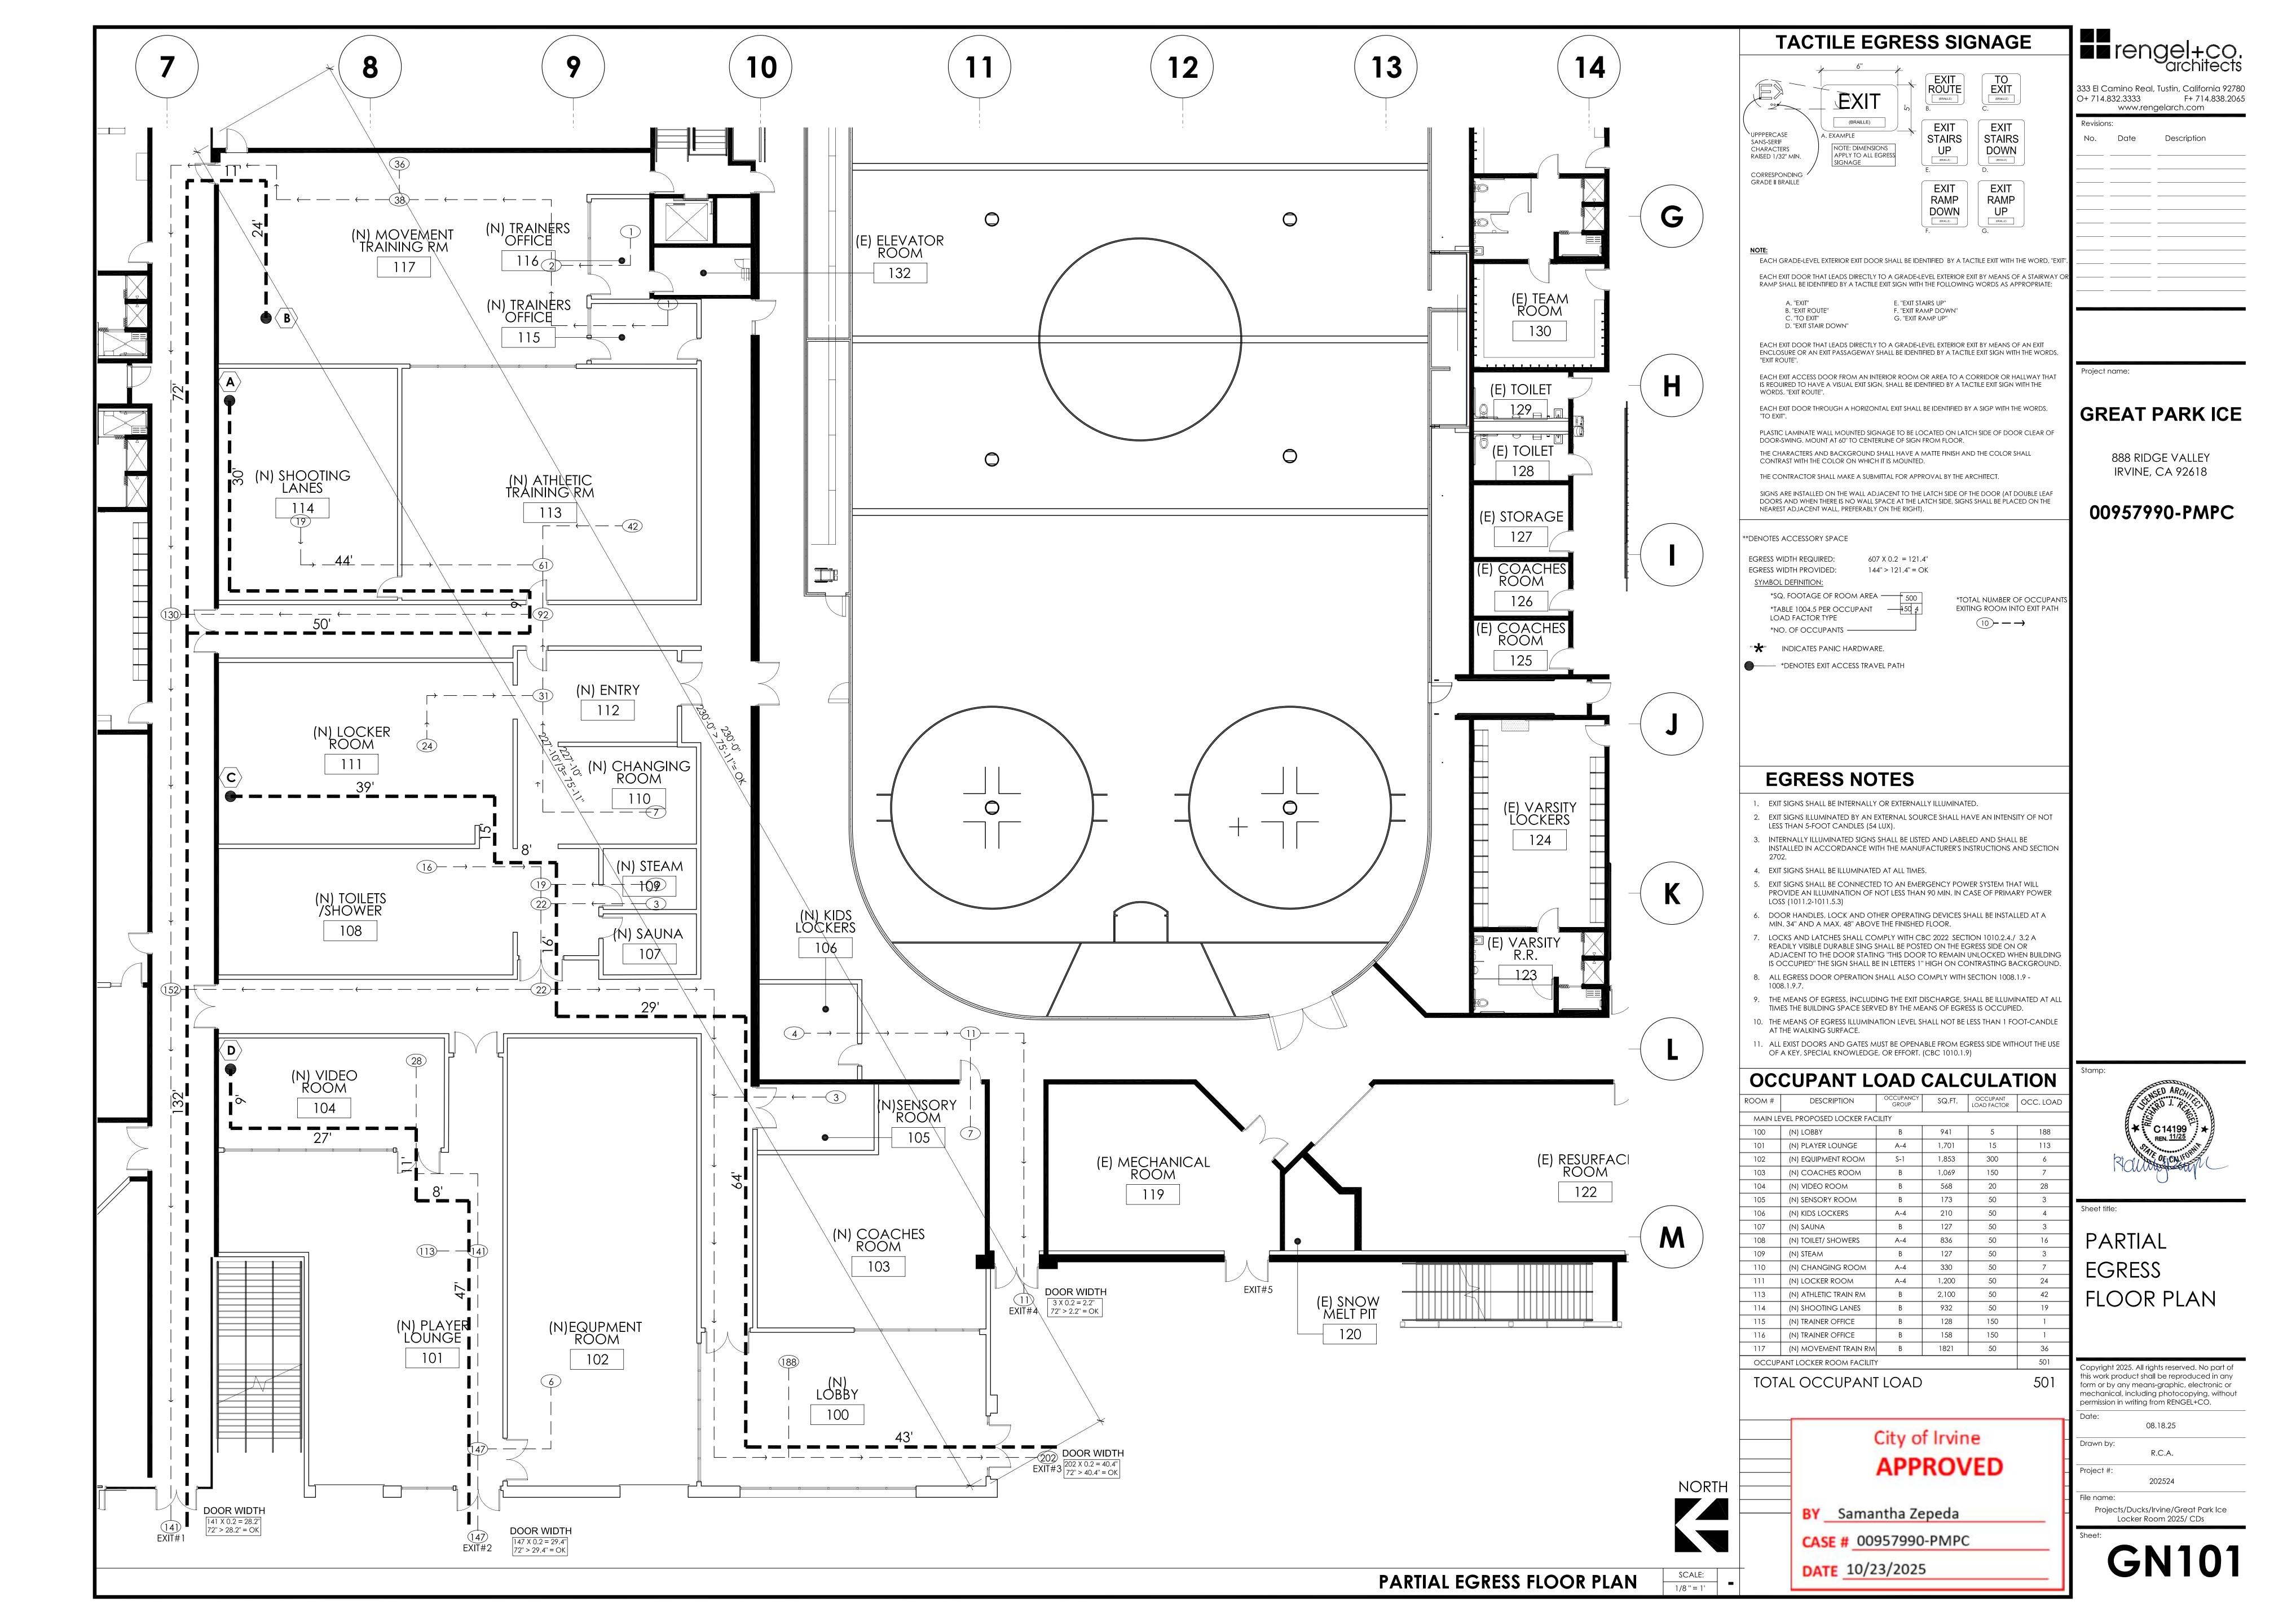

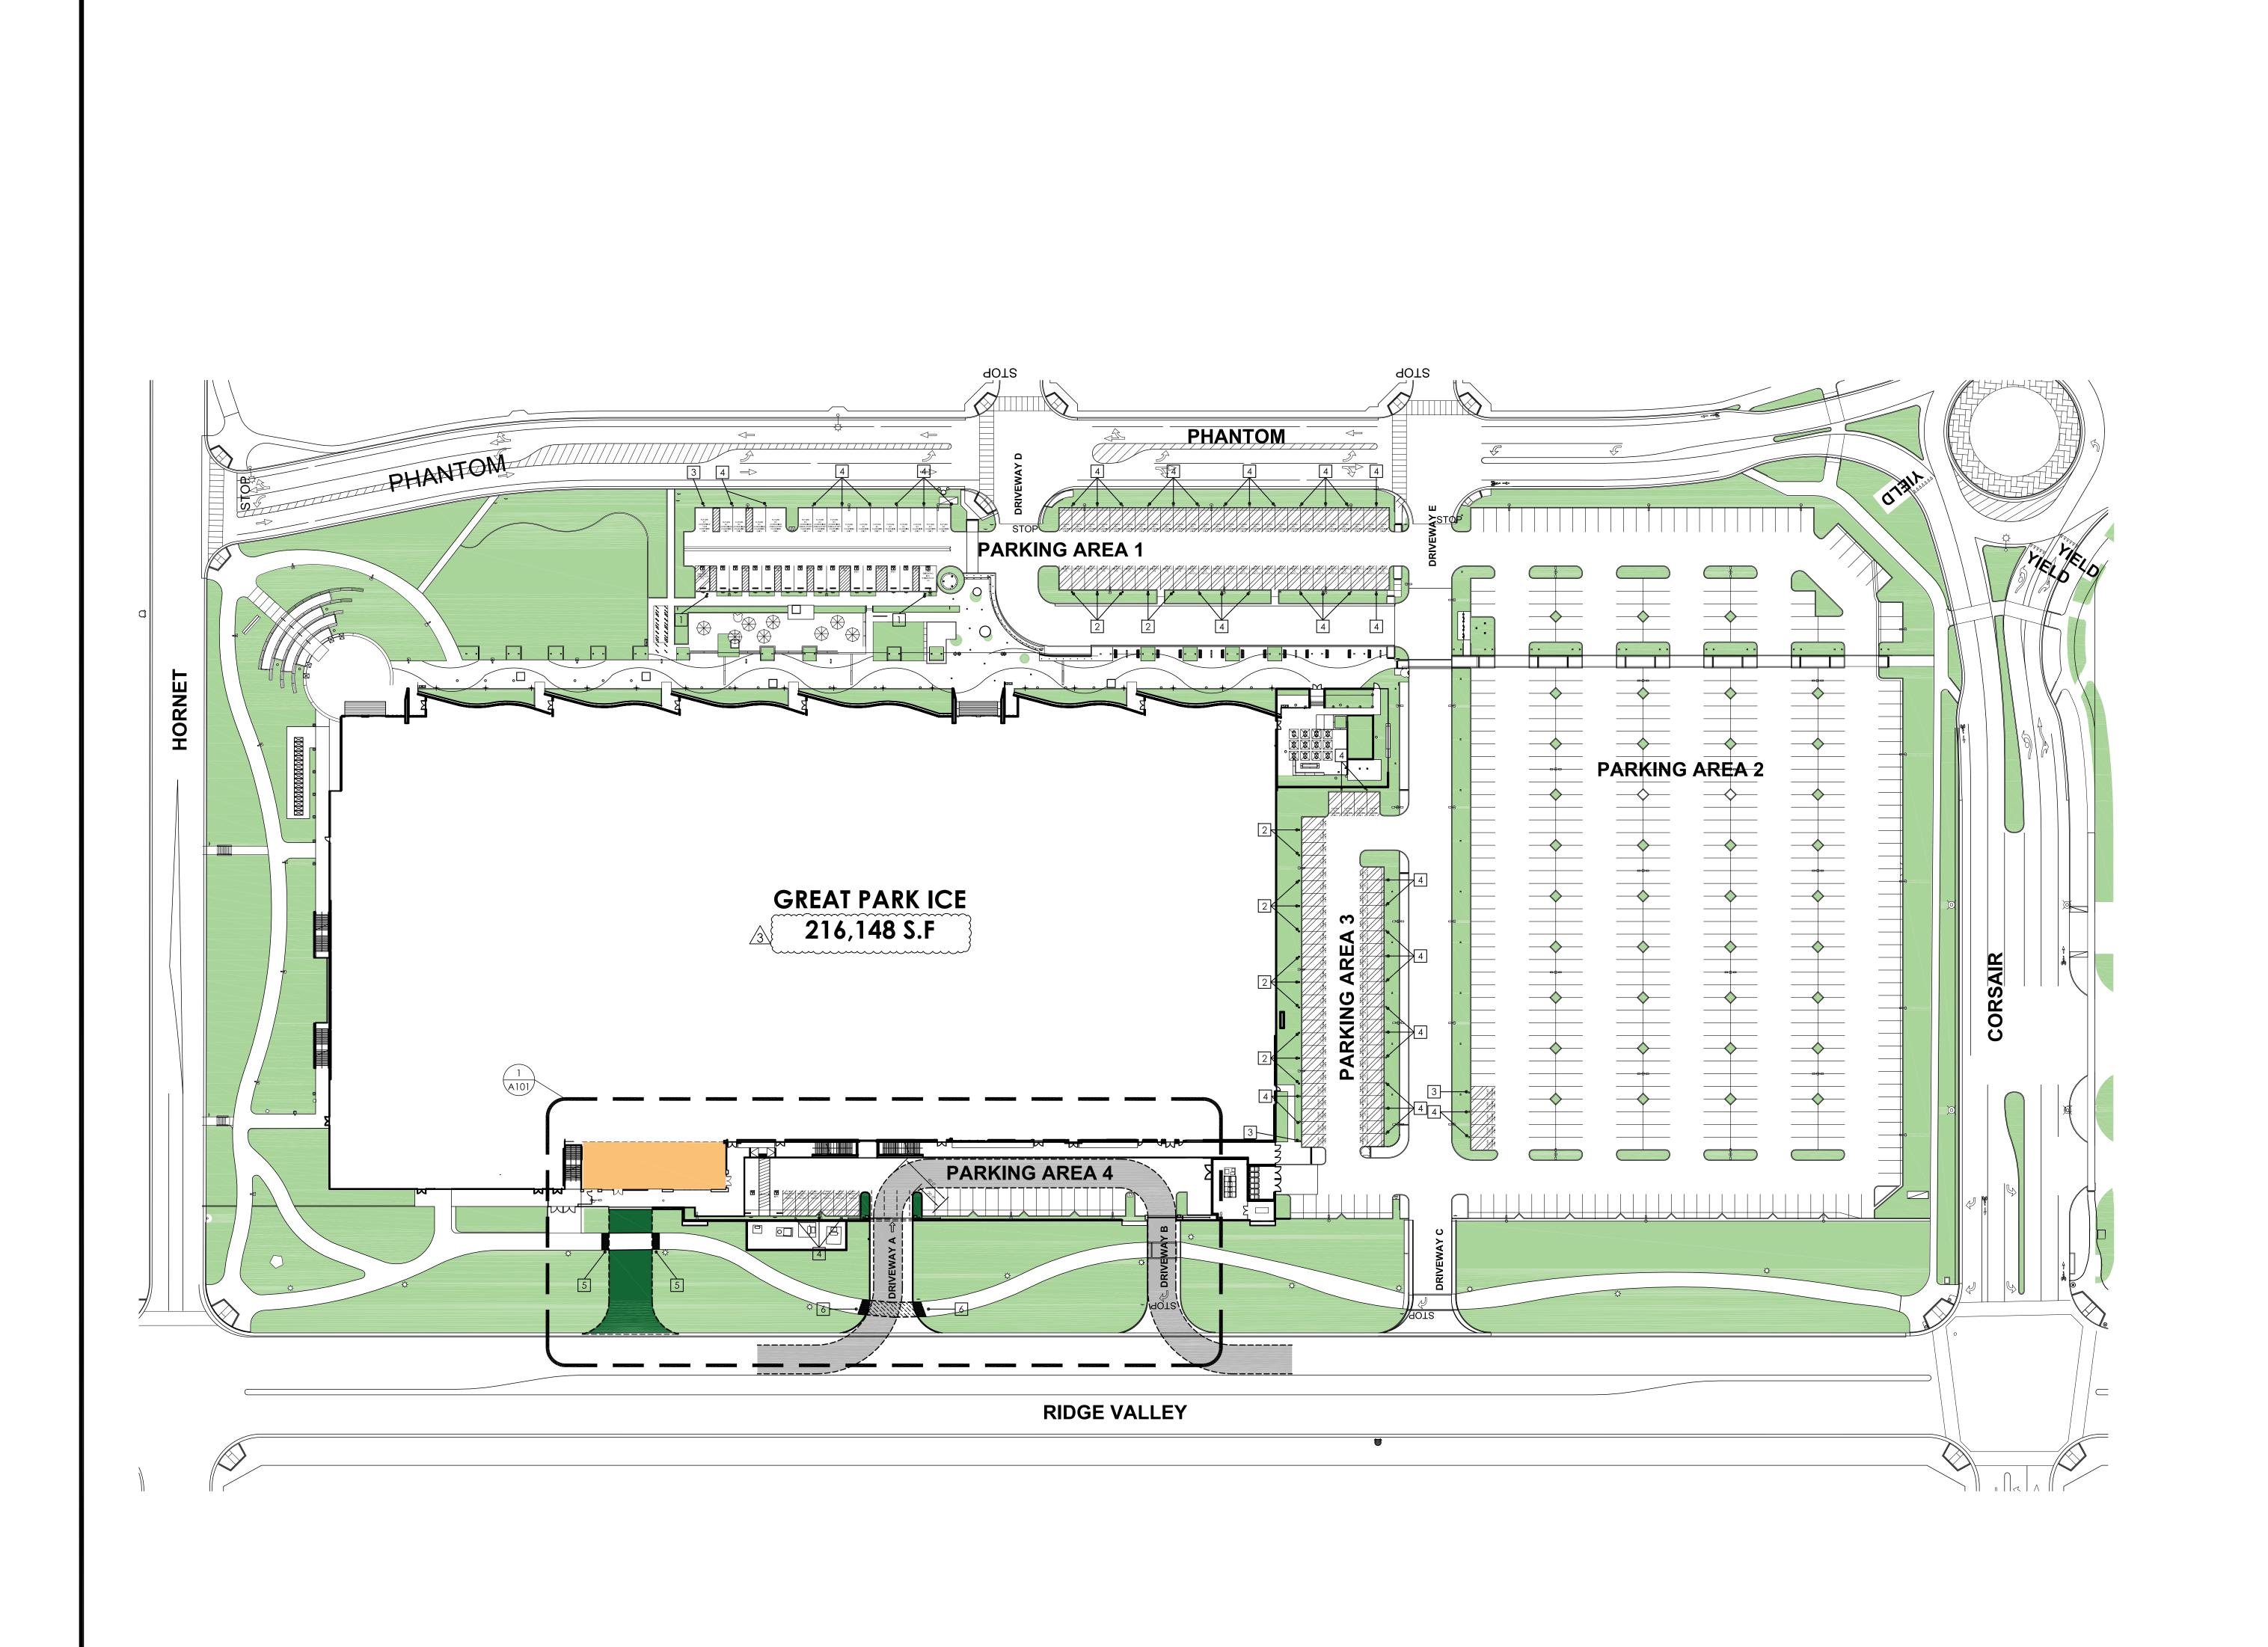

## **KEY NOTES**

PROJECT ADDRESS:	8000 GREAT PARK BLVD	, IRVINE, CA 926
PERMIT #:		00957990-PMI
APN#		580-765
ZONE:		
PLANNING AREA:		(GREAT PARK)
CONSTRUCTION TYPE:		1
EXISTING NUMBER OF STORIES:		
PROPOSED NUMBER OF STORIES:		
OCCUPANCY CLASSIFICATION:		S-2, A-4, B, F
FIRST FLOOR:		
SECOND FLOOR:		
ADDITION OCCUPANCY CLASSIFICATION:		A
SETBACKS:	REQUIRED	PROVI
STREET	50'-0''	140'-10 1
COMMUTER HIGHWAY/LOCAL	15'-0''	102'-8 1
SIDE	5'-0''	79'-5 1
REAR	10'-0''	102'-8 1
BUILDING TO BUILDING	0'-0''	N
SQUARE FOOTAGES:		,

SQUARE FOOTAGES:		00000000	
	<u>EXISTING</u>	NEW NEW	TOTAL
TOTAL SQUARE FOOTAGE:	267,202 S.F.	+ 3,033 S.F.	270,505
BUILDING FOOTPRINT:	212,739 S.F.	+ 3,409 S.F.	216,148
SITE AREA:		{	648,175
LOT COVERAGE:		سسسس	
PROPOSED:			33
ALLOWED:			65

DEMOLITION AREA:

PER 2022 CBC TABLE 506.2 A-4 OCCUPANCY, 'SM', TYPE 1-B= UNLIMITED S-2 OCCUPANCY 'SM', TYPE 1-B = 237,000 S.F.

237,000 S.F.> 13,300 S.F. = OK B OCCUPANCY, 'SM', TYPE 1-B = UNLIMITEDF OCCUPANCY, 'SM', TYPE 1-B = UNLIMITED M OCCUPANCY 'SM', TYPE 1-B = UNLIMITED

LANDSCAPE COVERAGE

EXISTING LANDSCAPING 195,454 S.F. PROPOSED DRIVEWAY REMOVAL - 2,840 S.F. PROPOSED DRIVEWAY NEW 2,864 S.F. PROPOSED TOTAL: 195,478 S.F. SITE LANDSCAPE COVERAGE REQUIRED 15% PROPOSED 30%

PARKING LOT COVERAGE existing

PROPOSED PARING LOT REMOVAL - 3,455 S.F. PROPOSED TOTAL 233,118 S.F. PARKING LOT COVERAGE EXISTING 37%

236,573 S.F.

36%

PROPOSED

EXISTING OCCUPANCY LOAD: LOAD FACTOR/ SQFT = TOTAL 3,303 / 50 =66 PROPOSED OCCUPANCY LOAD: TOTAL NEW OCCUPANCY LOAD:

OCCUPANCY CALCULATIONS

ACCORDING TO C.B.C.11B- TABLE 208.2, 9 ACCESSIBLE PARKING SPACES ARE REQUIRED.

# # KEYNOTES

1 NEW LEVEL-2 ELECTRIC VEHICLE CHARGING STATION (EVSE).

2 NEW LEVEL-2 ELECTRIC VEHICLE CHARGING STATION W/ DUEL CHARGER (EVSE). NEW INFRASTRUCTURE THAT WILL FACILITATE USE OF FUTURE LEVEL-2 ELECTRIC VEHICLE SUPPLY EQUIPMENT (EVSE)

NEW INFRASTRUCTURE THAT WILL FACILITATE USE OF FUTURE LEVEL-2 ELECTRIC VEHICLE SUPPLY EQUIPMENT (EVSE) WITH DUEL CHARGER 5 REMOVE TRUNCATED DOMES

6 PROVIDE NEW TRUNCATED DOMES

## PARKING TABULATION

REQUIRED PARKING;		6	
PROVIDED PARKING:			
STANDARD PARKING SPACES	9'x18'		
STANDARD ACCESSIBLE PARKING SPACES	9'x18'		
VAN ACCESSIBLE PARKING SPACE	9'x18'		
STANDARD EV PARKING SPACES (EVCS WITH EVSE)	9'x18'		
STANDARD ACCESSIBLE EV PARKING SPACE (EVCS WITH EVSE)	9'x18'		
VAN ACCESSIBLE EV PARKING SPACE (EVCS WITH EVSE)	12'x18'		
FUTURE STANDARD EV PARKING SPACES (EVCS)	9'x18'		
FUTURE EV STANDARD ACCESSIBLE PARKING STALL (EVCS)	9'x18'		
FUTURE EV VAN ACCESSIBLE PARKING STALL	12'x18'		
FUTURE EV AMBULATORY ACCESSIBLE PARKING STALL (EVCS)	10'x18'		

PROVIDED PARKING:		
STANDARD PARKING SPACES	9'x18'	
STANDARD ACCESSIBLE PARKING SPACES	9'x18'	
VAN ACCESSIBLE PARKING SPACE	9'x18'	
STANDARD EV PARKING SPACES (EVCS WITH EVSE)	9'x18'	
STANDARD ACCESSIBLE EV PARKING SPACE (EVCS WITH EVSE)	9'x18'	
VAN ACCESSIBLE EV PARKING SPACE (EVCS WITH EVSE)	12'x18'	
FUTURE STANDARD EV PARKING SPACES (EVCS)	9'x18'	
FUTURE EV STANDARD ACCESSIBLE PARKING STALL (EVCS)	9'x18'	
FUTURE EV VAN ACCESSIBLE PARKING STALL	12'x18'	
FUTURE EV AMBULATORY ACCESSIBLE PARKING STALL (EVCS)	10'x18'	
TOTAL PROVIDED PARKING		

LEGEND

PROPOSED TENANT IMPROVEMENT AREA

PROPOSED LANDSCAPE AREA

EXISTING LANDSCAPE AREA



# INC

NORTH

SCALE: 1" = 50'-0"

City of Irvine **APPROVED** 

BY Samantha Zepeda

DATE 10/23/2025

CASE # 00957990-PMPC

O+ 714.832.3333 F+ 714.838.2065


www.rengelarch.com

Project name:

**GREAT PARK ICE** 

888 RIDGE VALLEY IRVINE, CA 92618

00957990-PMPC

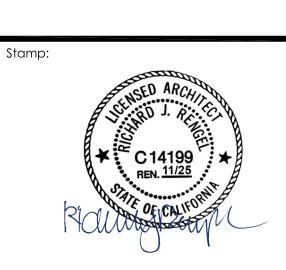


SITE PLAN


Copyright 2025. All rights reserved. No part of this work product shall be reproduced in any form or by any means-graphic, electronic or mechanical, including photocopying, without permission in writing from RENGEL+CO.

> 08.18.25 R.C.A. Project #: 202524

Projects/Ducks/Irvine/Great Park Ice Locker Room 2025/ CDs

A100

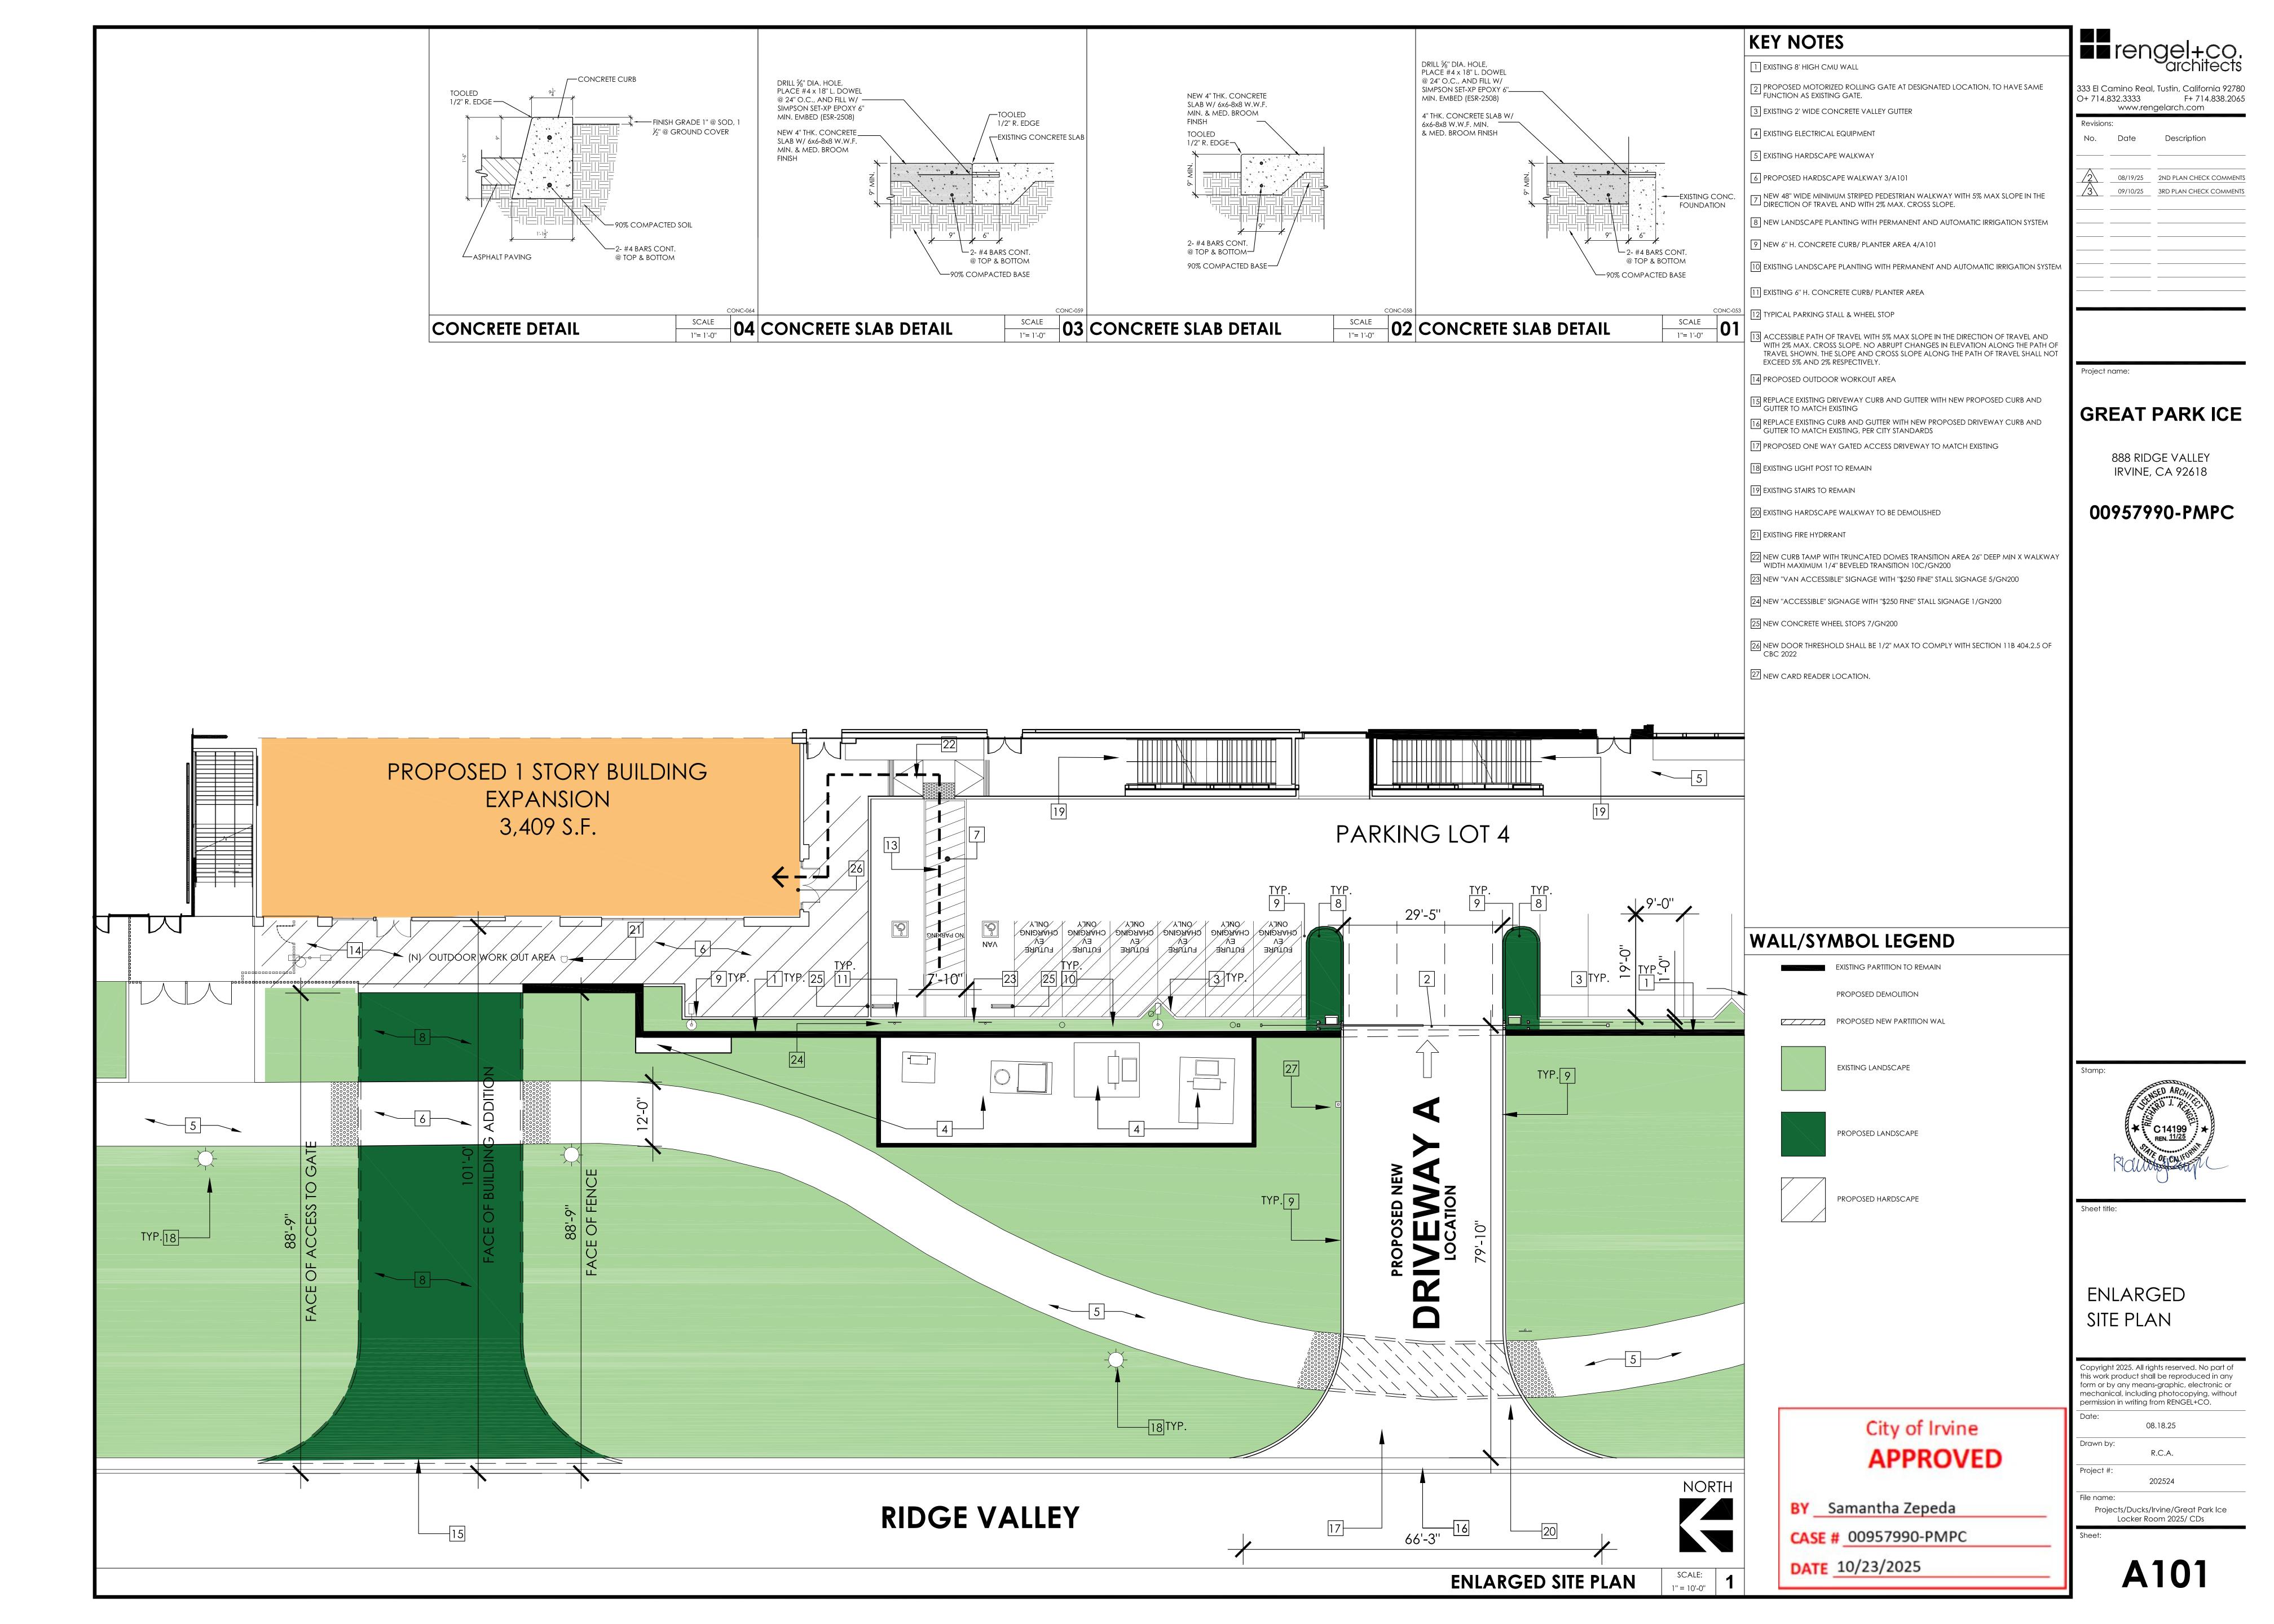

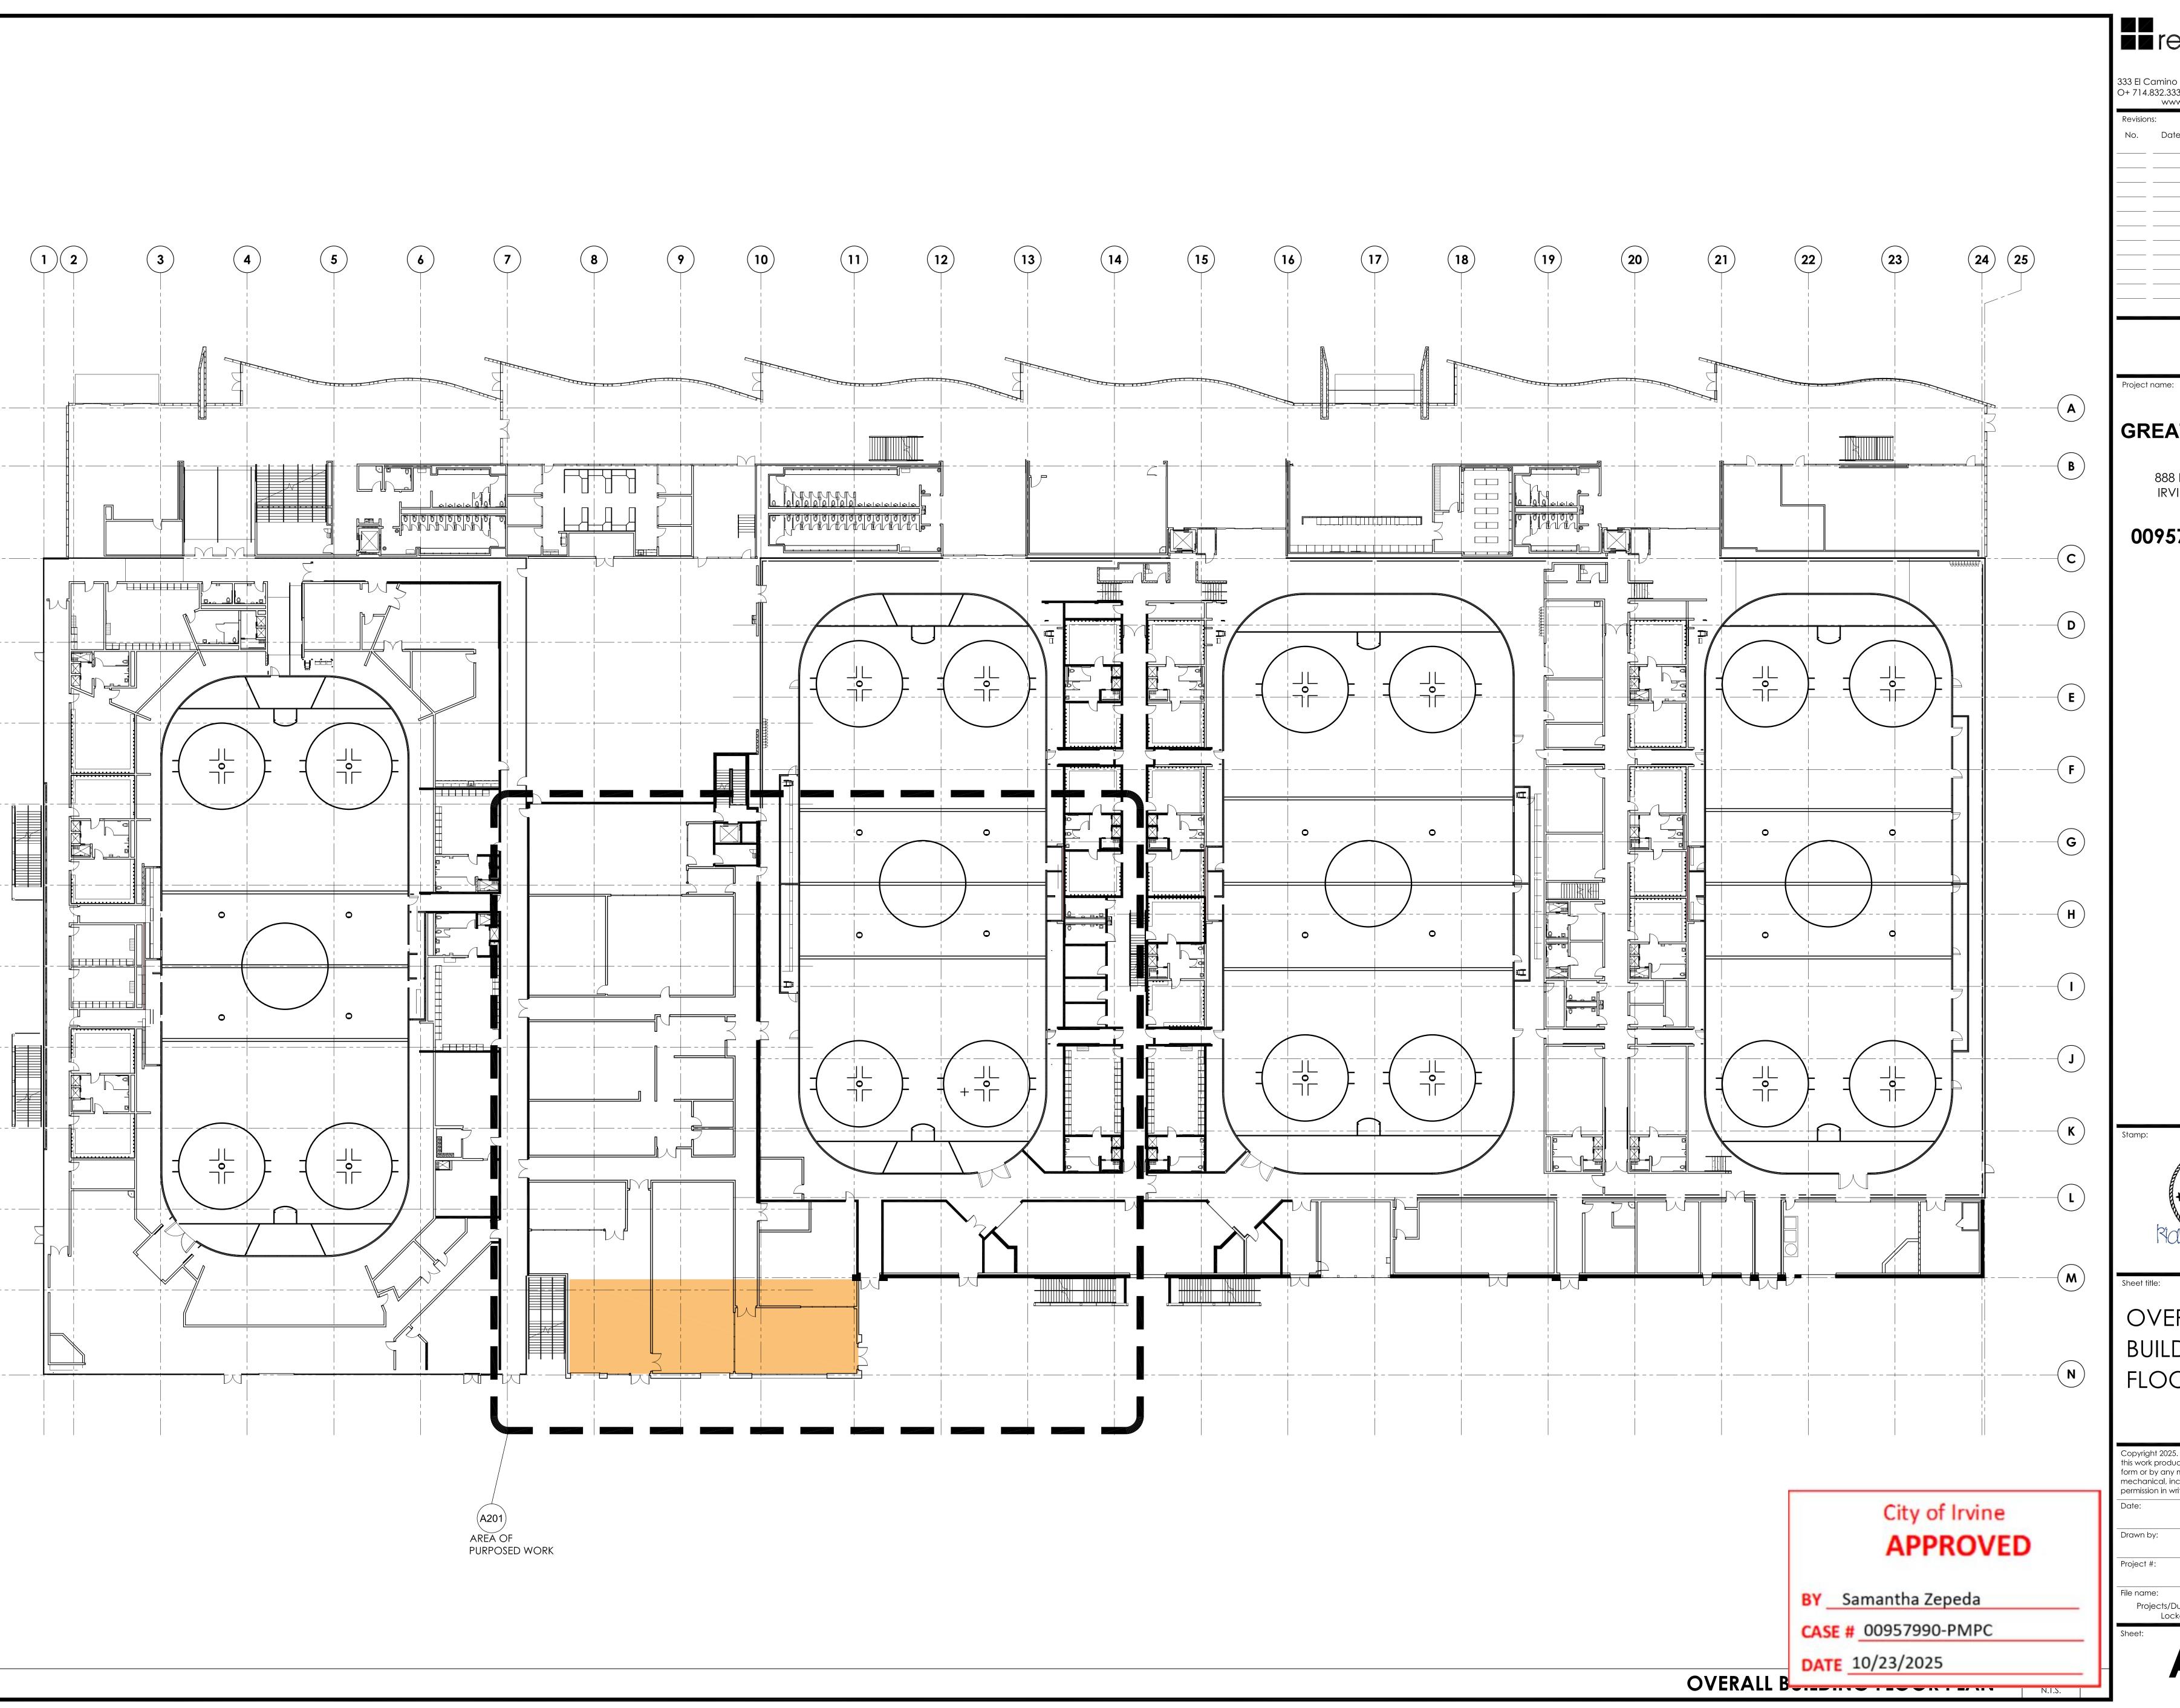

rengel+co.
architects

333 El Camino Real, Tustin, California 92780 O+ 714.832.3333 F+ 714.8 www.rengelarch.com F+ 714.838.2065

**GREAT PARK ICE** 

888 RIDGE VALLEY IRVINE, CA 92618

00957990-PMPC




OVERALL BUILDING FLOORPLAN

Copyright 2025. All rights reserved. No part of this work product shall be reproduced in any form or by any means-graphic, electronic or mechanical, including photocopying, without permission in writing from RENGEL+CO.

08.18.25 R.C.A. Project #:

202524

Projects/Ducks/Irvine/Great Park Ice Locker Room 2025/ CDs

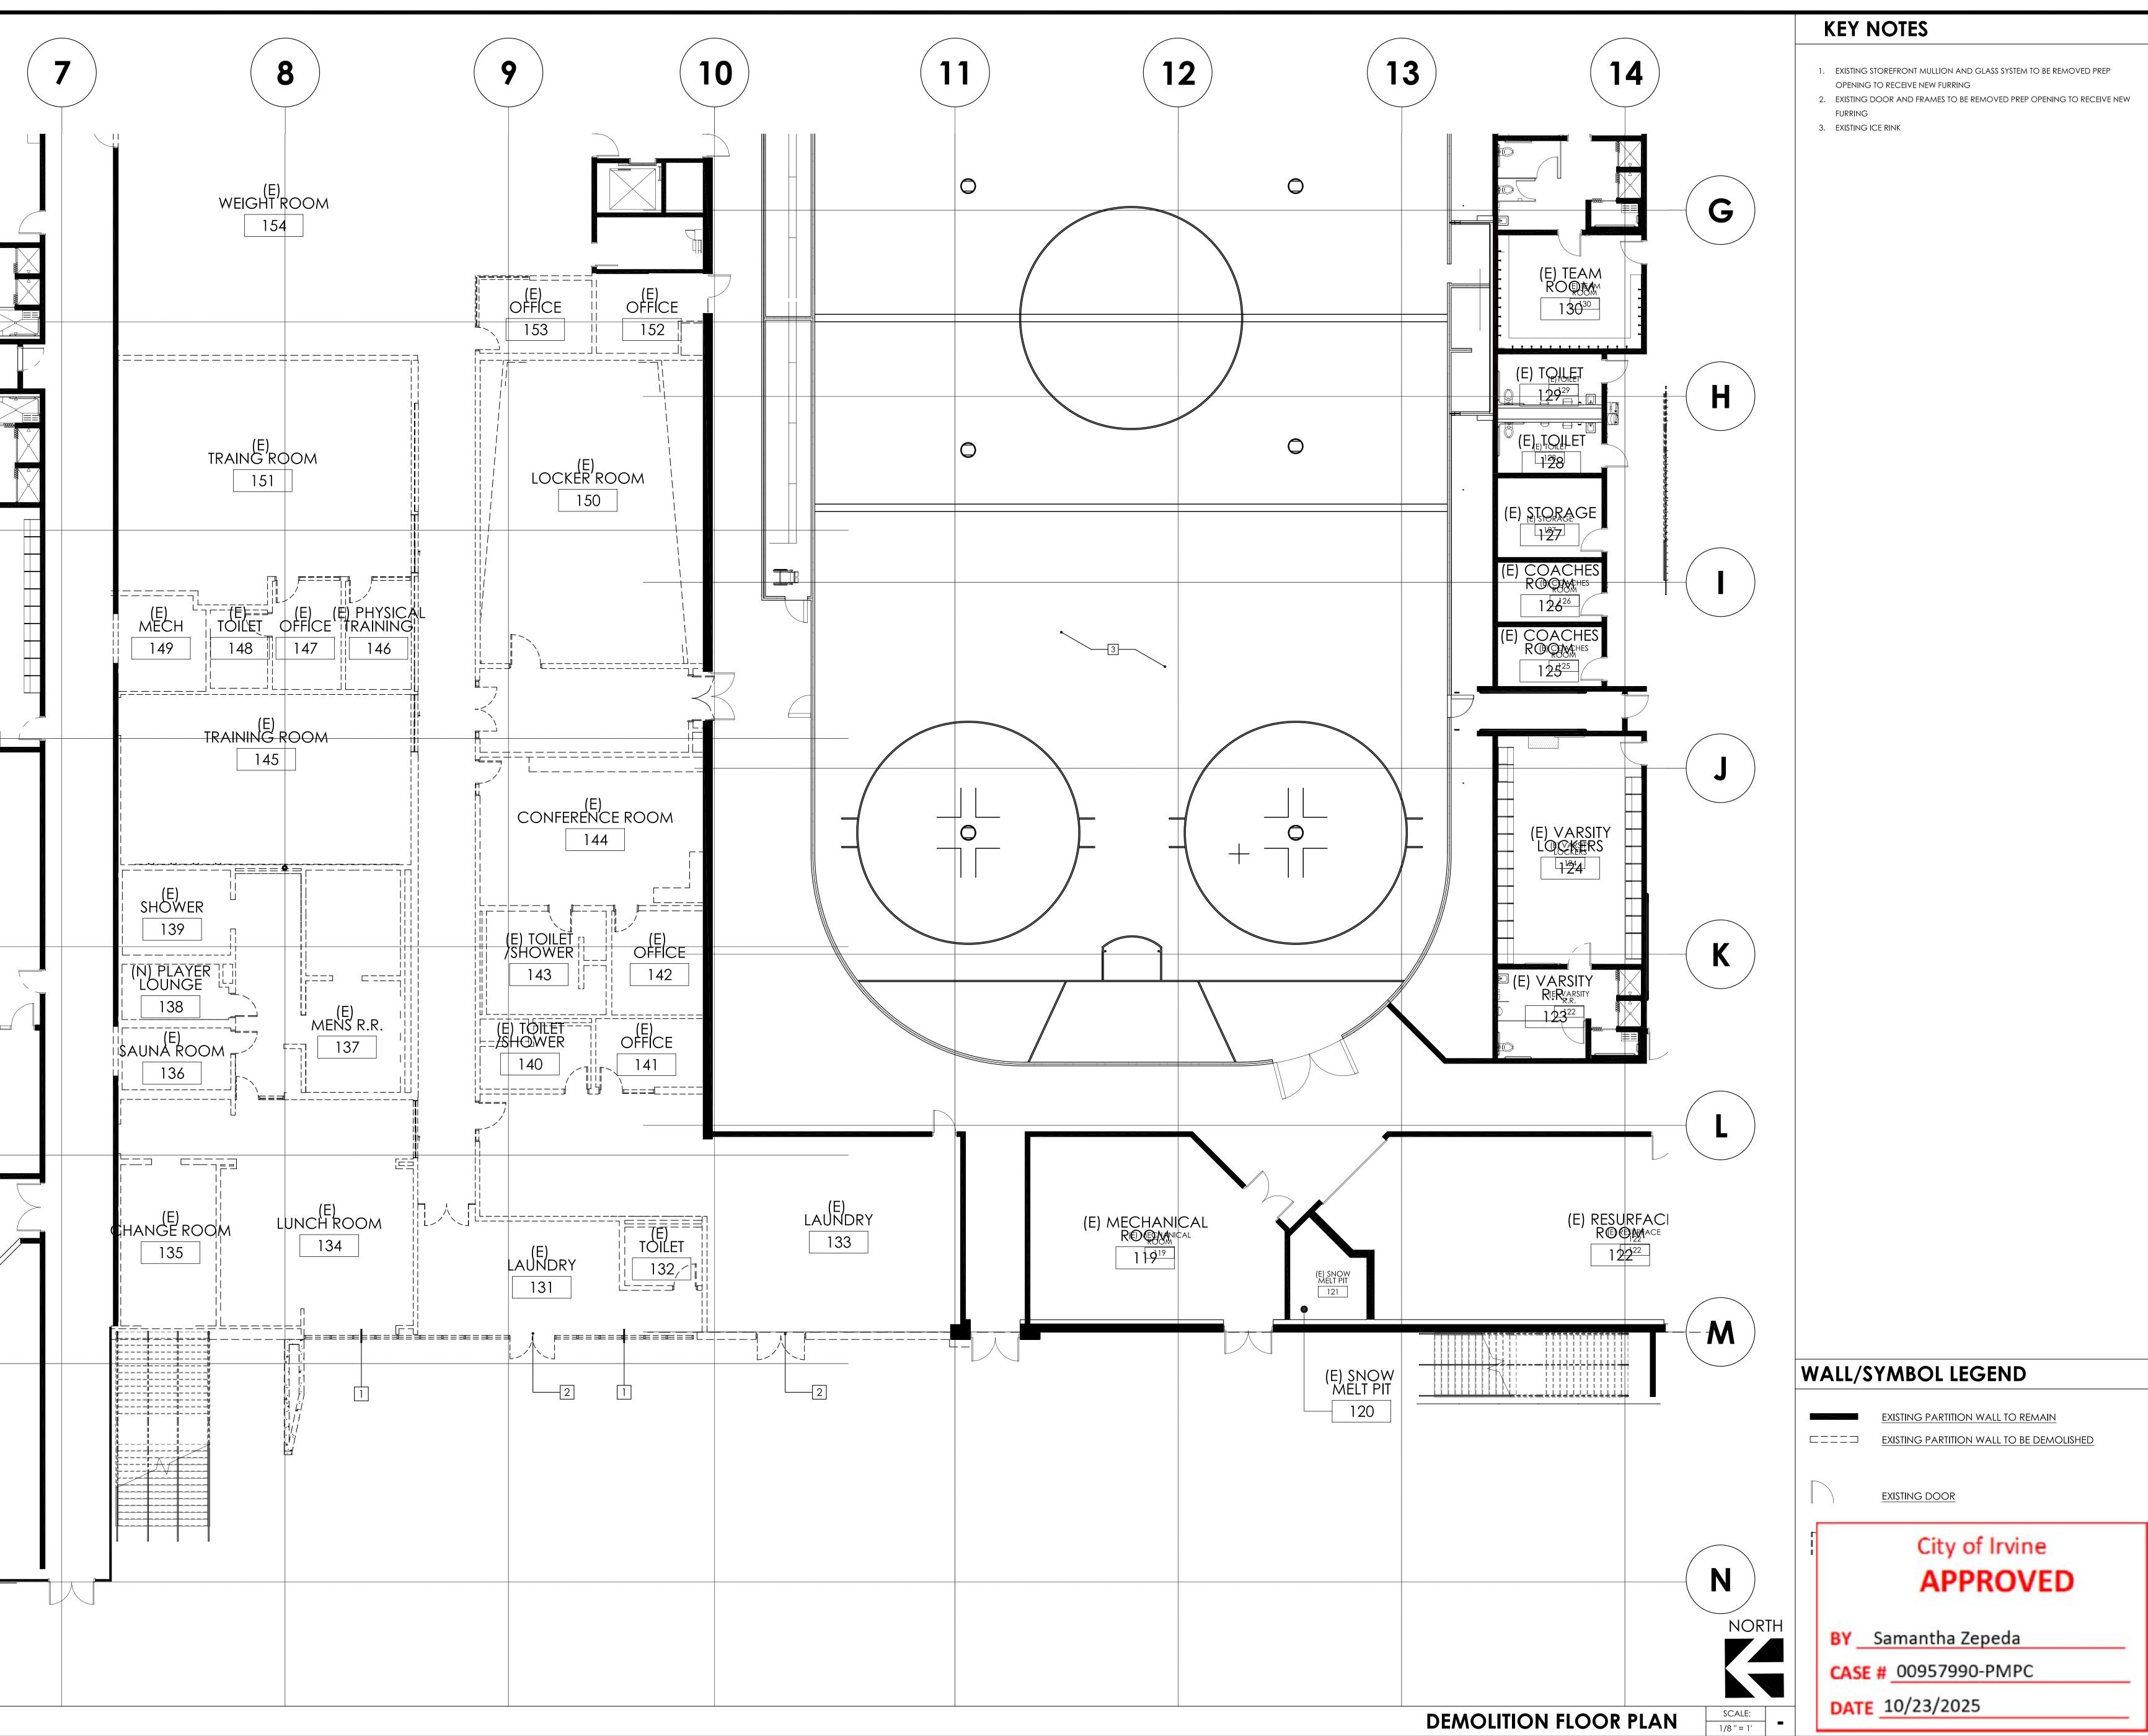

333 El Camino Real, Tustin, California 92780

O+ 714.832.3333

www.rengelarch.com


F+ 714.838.2065

Project name:

**GREAT PARK ICE** 

888 RIDGE VALLEY IRVINE, CA 92618

00957990-PMPC

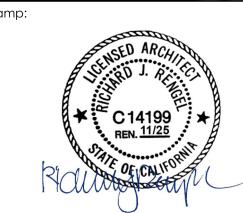

DEMOLITION


FLOOR PLAN

Copyright 2025. All rights reserved. No part of this work product shall be reproduced in any form or by any means-graphic, electronic or mechanical, including photocopying, without permission in writing from RENGEL+CO.

08.18.25

R.C.A. Project #: 202524

File name: Projects/Ducks/Irvine/Great Park Ice Locker Room 2025/ CDs

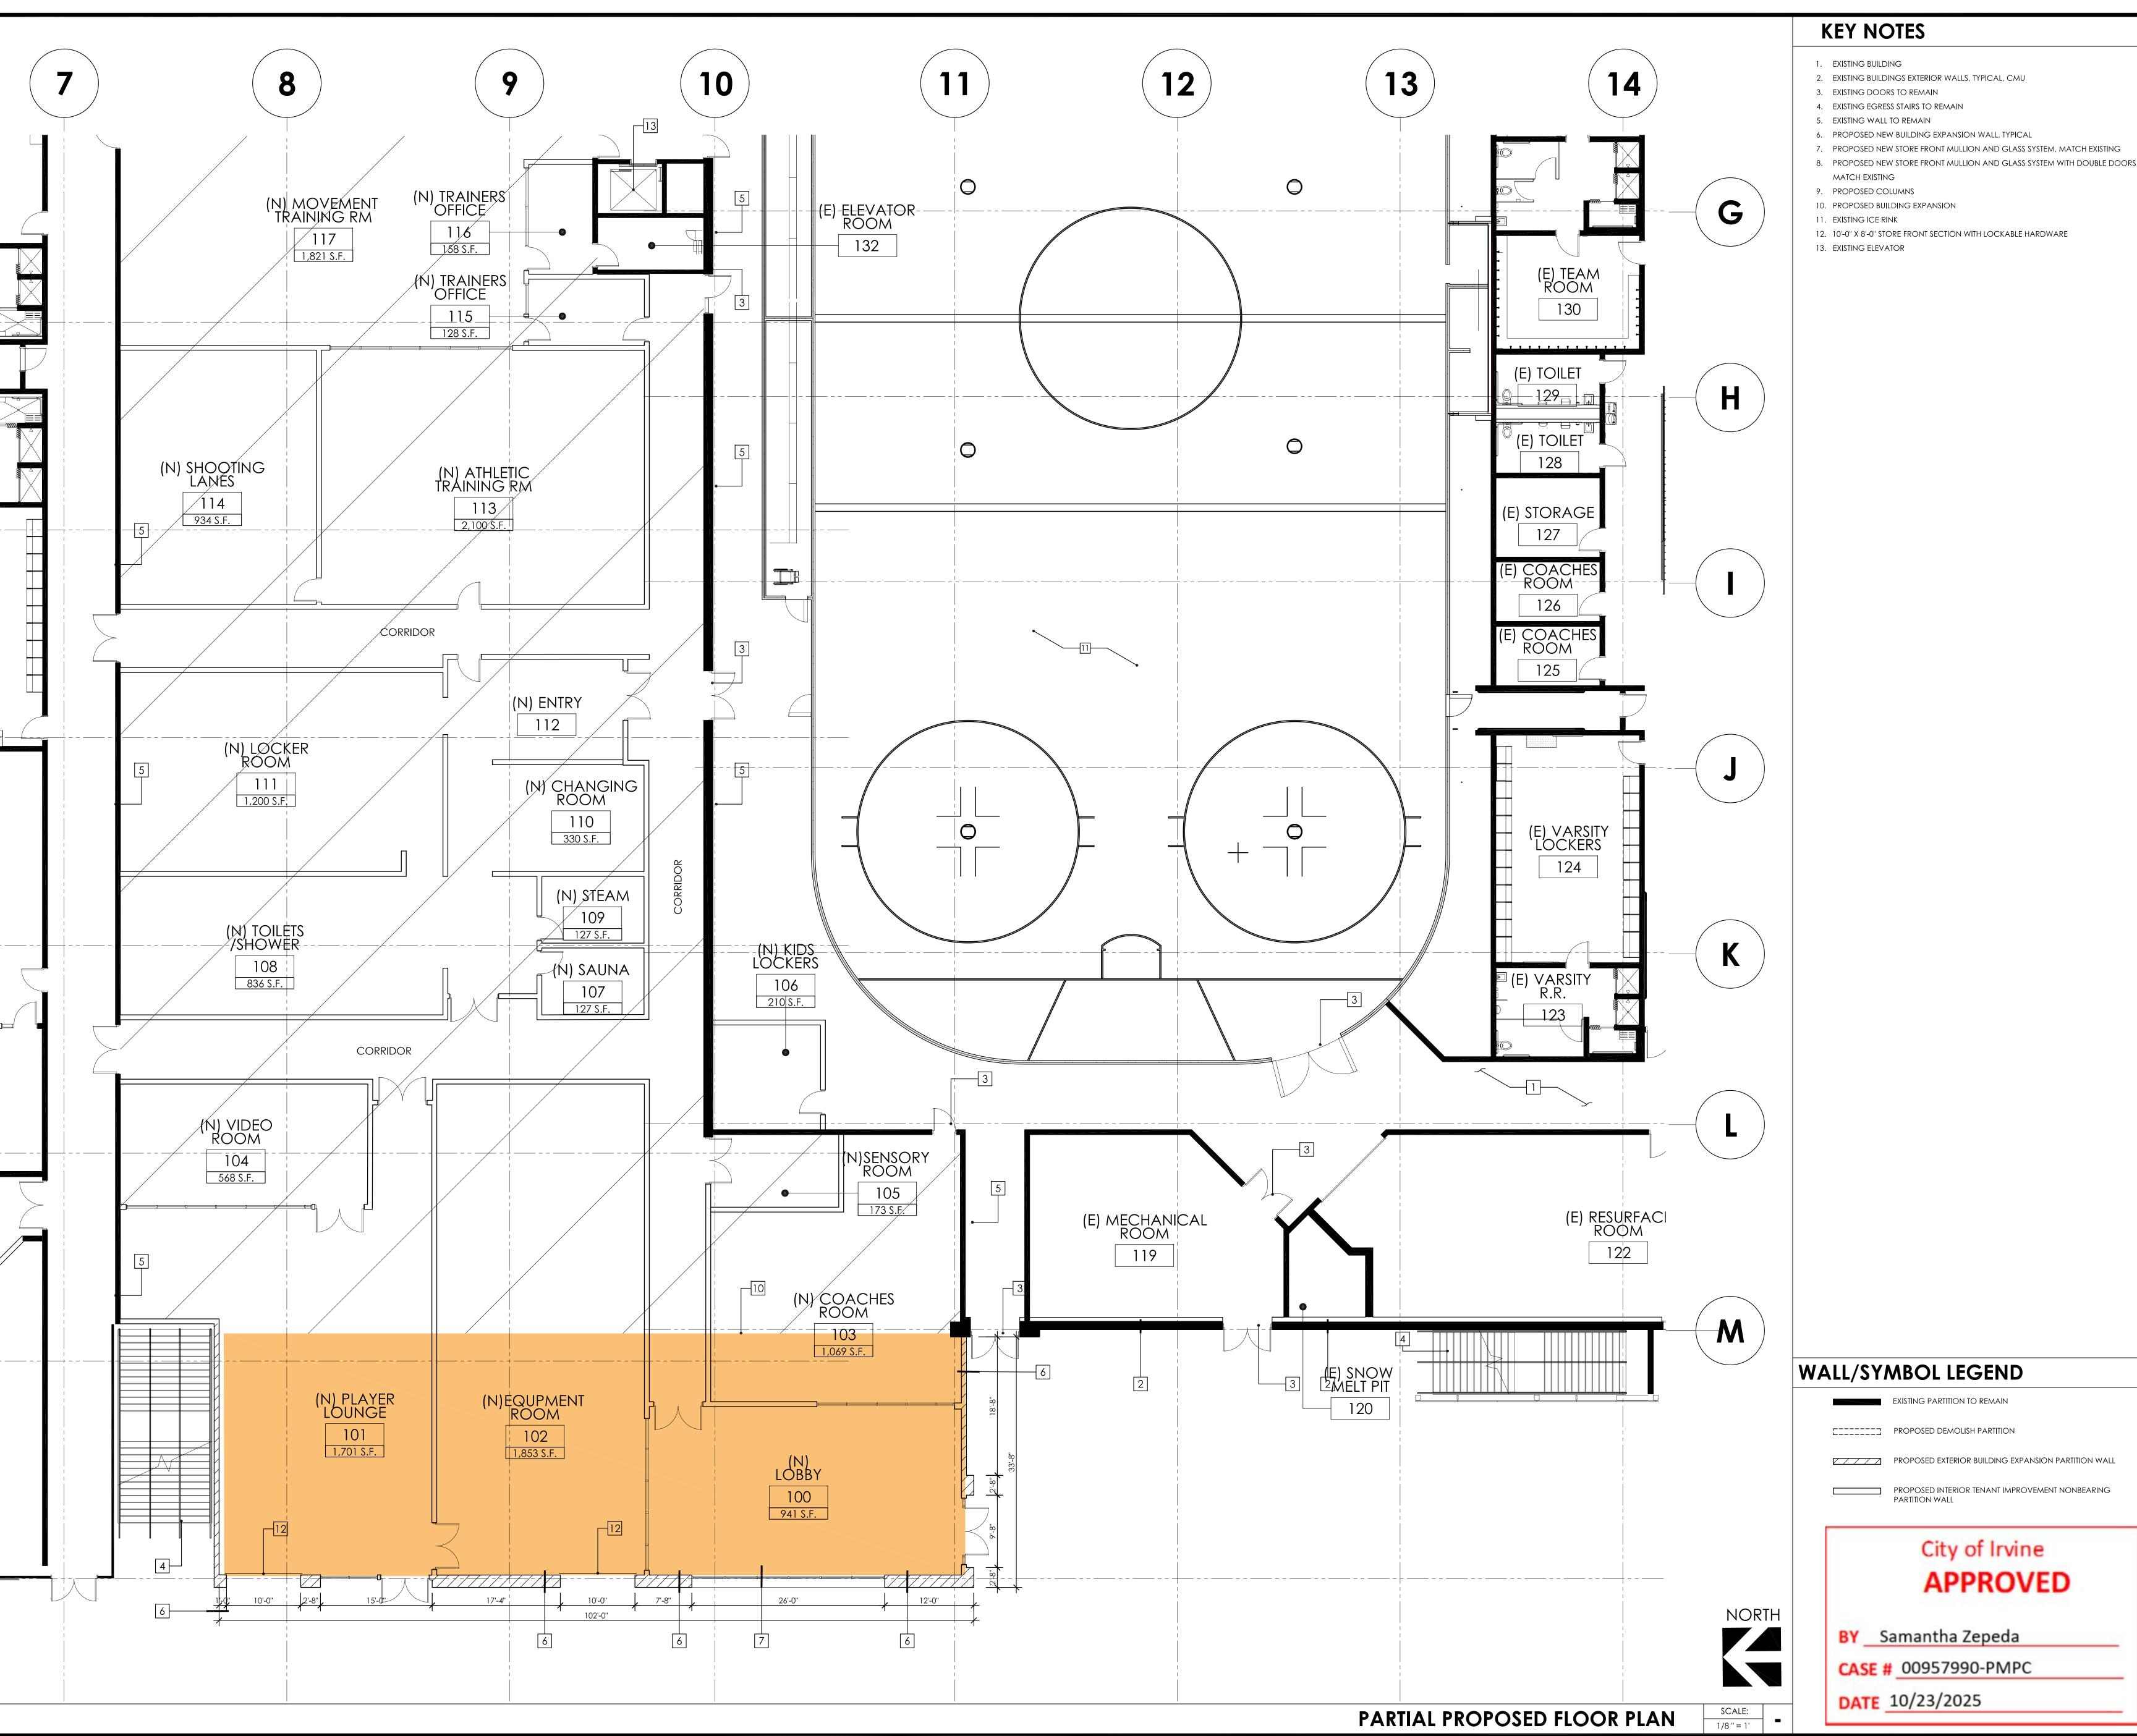

333 El Camino Real, Tustin, California 92780

F+ 714.838.2065

www.rengelarch.com


O+ 714.832.3333

Project name:

**GREAT PARK ICE** 

888 RIDGE VALLEY IRVINE, CA 92618

00957990-PMPC

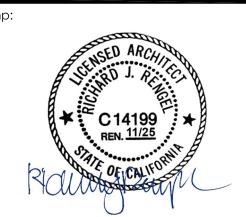

ENLARGED FLOOR PLAN


Copyright 2025. All rights reserved. No part of this work product shall be reproduced in any

form or by any means-graphic, electronic or mechanical, including photocopying, without permission in writing from RENGEL+CO. 08.18.25


R.C.A. Project #:


202524

Projects/Ducks/Irvine/Great Park Ice Locker Room 2025/ CDs

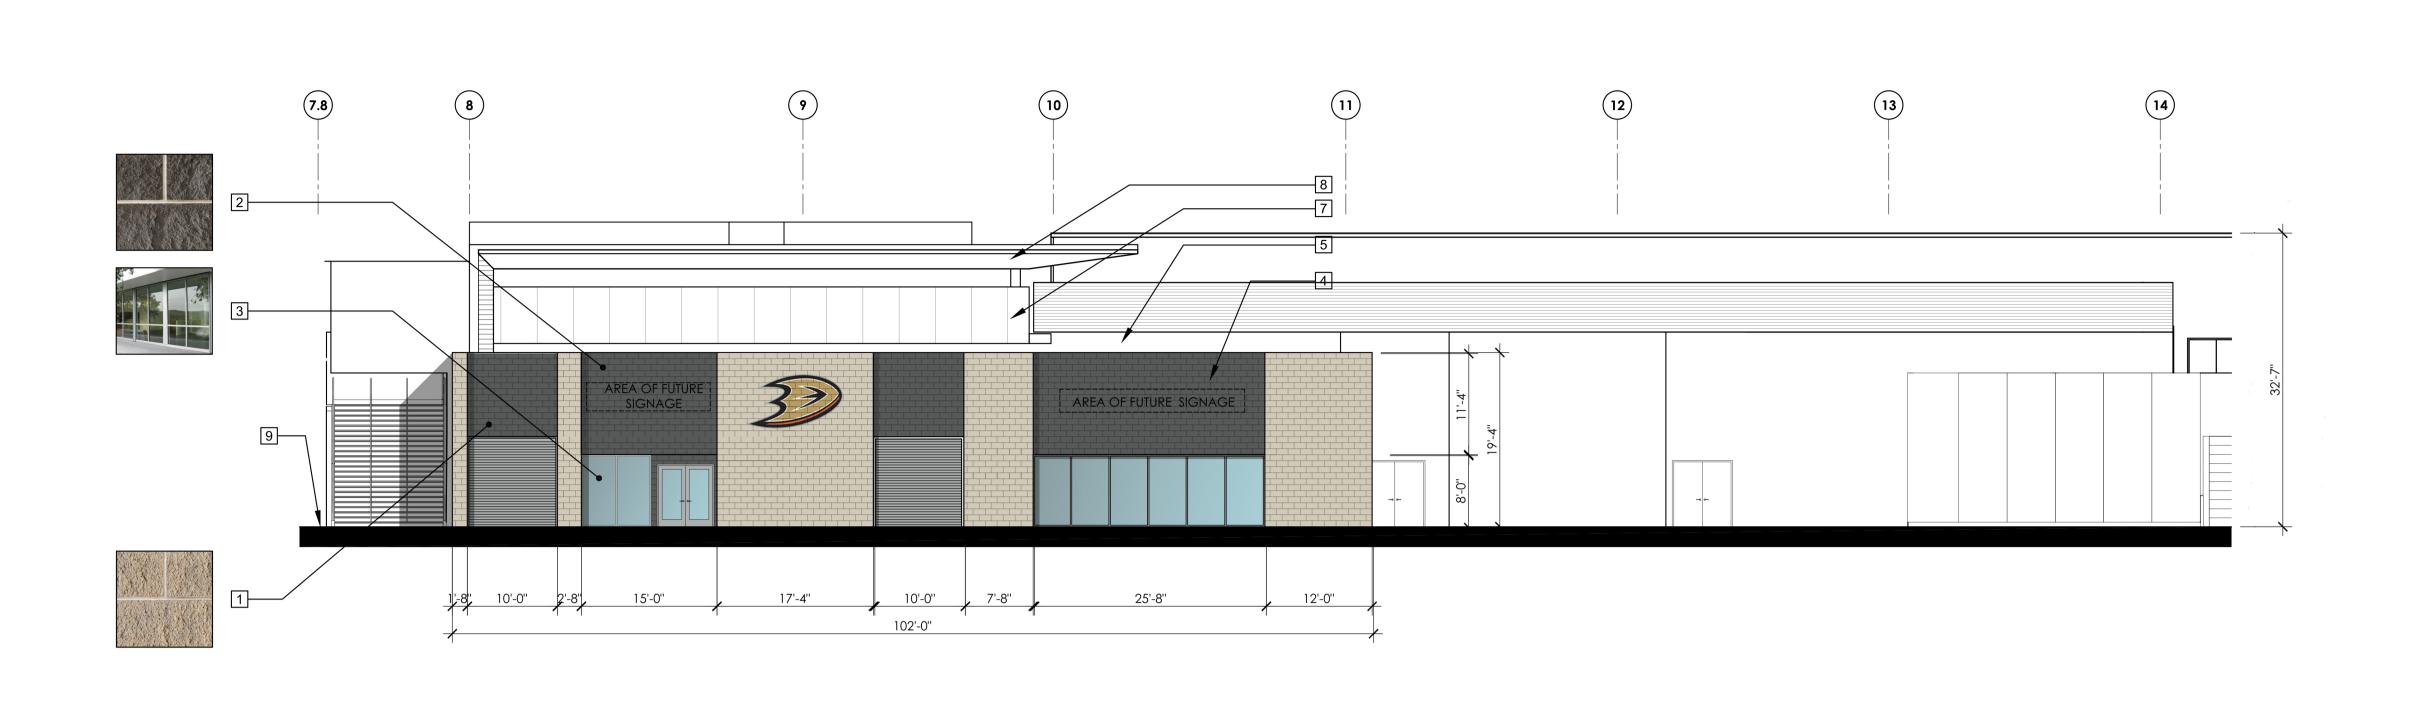

# PARTIAL WEST ELEVATION

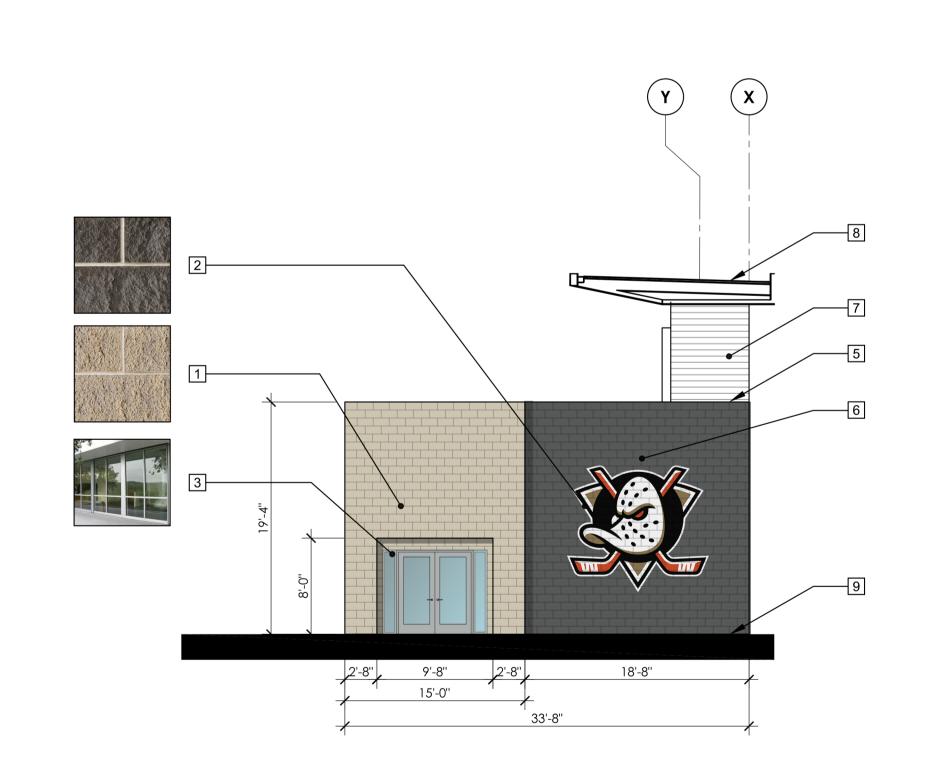

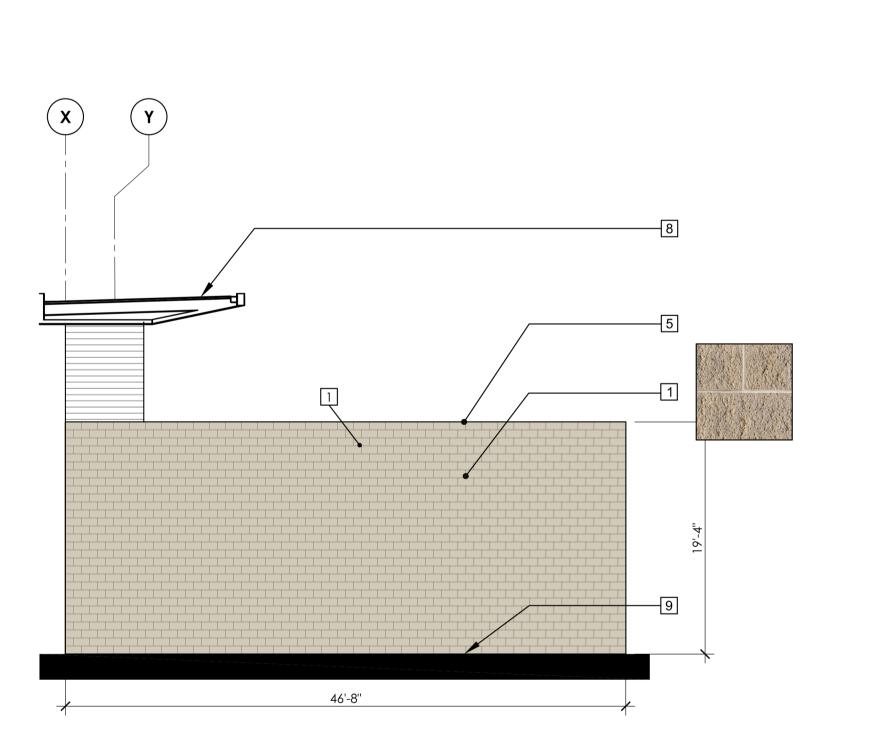

# KEYNOTES

9 FINISH WALKWAY SURFACE EXISTING

1 NEW CMU, NATURAL GRAY, BRICK TO MATCH EXISTING 2 NEW CMU, MIDNIGHT, TO MATCH EXISTING 3 NEW STOREFRONT WINDOWS AND DOOR 4 AREA OF FUTURE SIGNAGE SUBJECT TO SEPARATE REVIEWAND PERMITTING 5 PROPOSED TOP OF PARAPET WALL 6 PROPOSED DUCKS LOGO 7 EXISTING BUILDING SOFFIT WALL TO REMAIN 8 EXISTING TOP OF PARAPET

333 El Camino Real, Tustin, California 92780 O+ 714.832.3333 F+ 714.838.2065 www.rengelarch.com

No. Date Description


Project name:

# **GREAT PARK ICE**

888 RIDGE VALLEY IRVINE, CA 92618

00957990-PMPC

PARTIAL ELEVATIONS

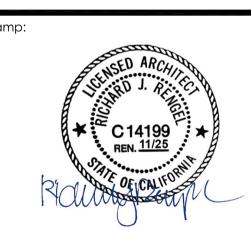

**A300** 

this work product shall be reproduced in any form or by any means-graphic, electronic or mechanical, including photocopying, without permission in writing from RENGEL+CO.

05.15.25 Drawn by: R.C.A.

Project #: 202251 File name:

Projects/Great Park Ice

City of Irvine **APPROVED** 

BY Samantha Zepeda

CASE # 00957990-PMPC

PARTIAL SOUTH ELEVATION

SCALE:

1/8" = 1'-0"

3

PARTIAL NORTH ELEVATION

DATE 10/23/2025